

NOTES

- All dimensions are in metres unless stated otherwise.
- Do not scale from this drawing. Only written dimensions are to be used.
- This drawing should be read in conjunction with the Architect's and Structural Engineer's design drawings and specification.
- 100mm & 150mm diameter pipework to be extra strength vitrified clay to BS EN 295 or BS 65 on Class S bed & surround.
- 225mm pipe work to be extra strength vitrified clay to BSEN295 or BSEN65 or concrete class M to BSEN5911 on class s bed F surround.
- Where cover to pipes is less than 1.2m concrete bed and surround should be used. Where pipes with flexible joints are used the concrete protection shall be interrupted across its full cross-section with a compressible filler.
- Stoppered connection end of pipe to have suitable stopper applied and connected to wire which is to be connected to a stake marking the end of the pipe at ground level if laterals are to be buried during construction phase.
- Refer to geotechnical report for sulphate resisting class and ACEC class.
- All construction to be in accordance with Sewers for Adoption - 6th Edition & Interim Addendum and Southern Water specific requirements.
- This drawing should be read in conjunction with other Foul Water Sewer Longitudinal Sections, S104 Adoption Layout (DSM/E4761/402), Foul Water Sewer Manhole Schedules (DSM/E4761/412), S104 Construction Details (DSM/E4761/410 to 411), and Domestic Drainage Layouts (DSM/E4761/451 to 455).
- Topographic Survey as per Stiline Level Survey, drawing number 657PG01 dated July 2012. Additional Topographic Survey as per ADA Solutions Ltd Topographical Survey, drawing number 0614-HP2-T1 dated June 2014. Ditch survey based on Stiline Ditch Level Survey, drawing number 657PG05 dated January 2019. Refer to these surveys for survey station coordinates and levels.]

12. ANY VARIANCE OR DISCREPANCY MUST BE REPORTED BACK TO RCP ENGINEERING BEFORE WORK BEGINS.

CDM NOTES

- EXISTING SERVICES. Depth of existing services must be determined prior to works commencing. The contractor is responsible for establishing underground services in accordance with HSE Guidance note HS (G) 47. Any services which would be within the proposed construction layers must be lowered to below the sub-base.

Client:-

DREW SMITH LIMITED

Site:-

SUMMER LANE
PAGHAM

Drawing Title:-

FOUL WATER SEWER
LONGITUDINAL
SECTIONS

Sheet 2 of 2

Date: February 2020

Scales: H=1:500, V=1:100 at A1

Drawn: GD-I

Checked: PJ

Approved: TRS

Drawing No.

DSM/E4761/202 B

INITIAL TENDER ISSUE


SUBJECT TO PLANNING APPROVAL



Rogers Cory Partnership
Architectural and Civil Consultants
The Old School Old School Road
Hook Hampshire RG27 9NJ

T: 01256 769269 E: mail@rcpconsultants.co.uk W: rcpconsultants.co.uk

Onsite Infrastructure Works Offsite S104

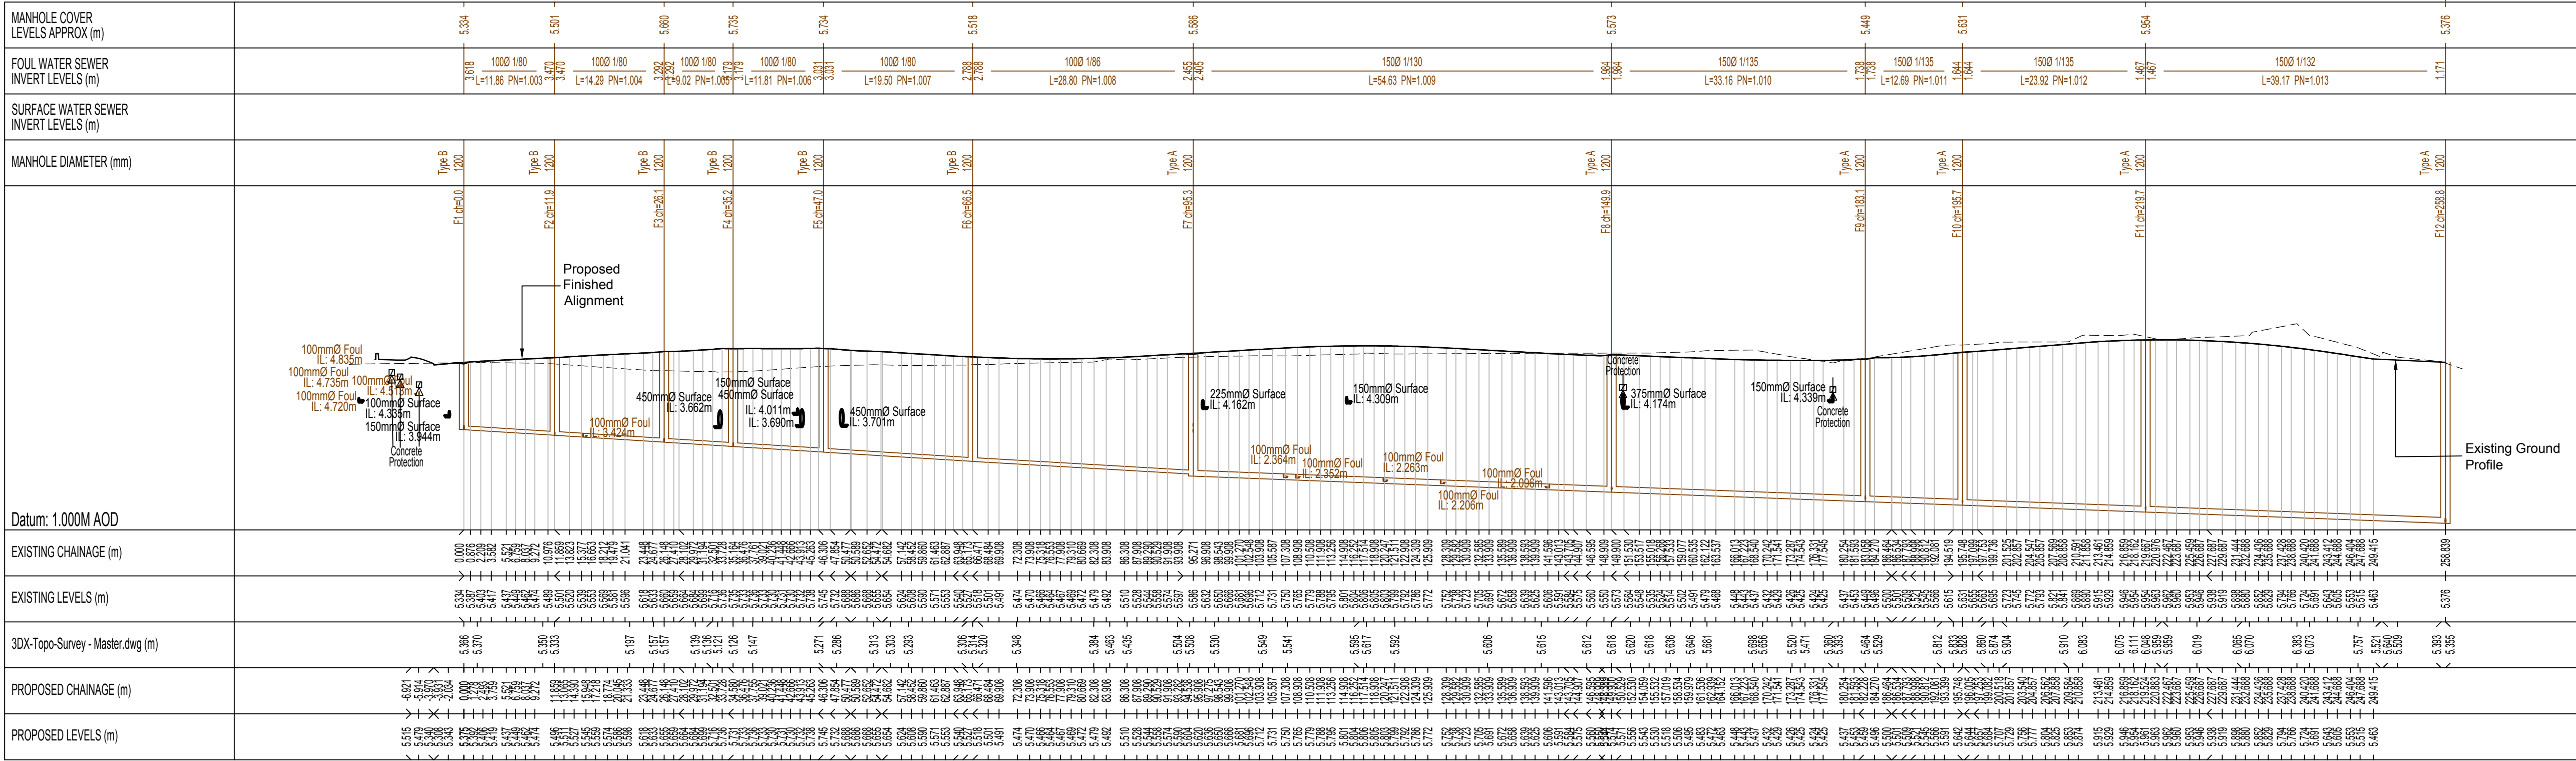

SCALE BAR 1:500 at A1

B	06.03.20	Schedules updated to suit new manhole layout.	GD-I	LD	TRS
A	28.02.20	Inlet manhole F20 location updated. Long section updated.	GD-I	LD	TRS
Rev.	Date	Details	By	Chkd	Appd