



- GENERAL NOTES :
1. This drawing is the copyright of Kenn Scaddan Associates Ltd and may not be copied, altered or reproduced in any form or passed on to a third party without written consent. If in doubt ASK.
 2. The drawing reflects current standards and legislation agreed for this project at the time of original issue.
 3. This drawing is to be read in conjunction with all relevant architects, structural engineers, mechanical & electrical engineers and specialists drawings / specifications.
 4. Any discrepancies in dimensions or details between the various drawings should be reported immediately.
 5. All dimensions are in millimetres and all levels are in meters.
 6. Do not scale from this drawing for construction, if in doubt ASK.

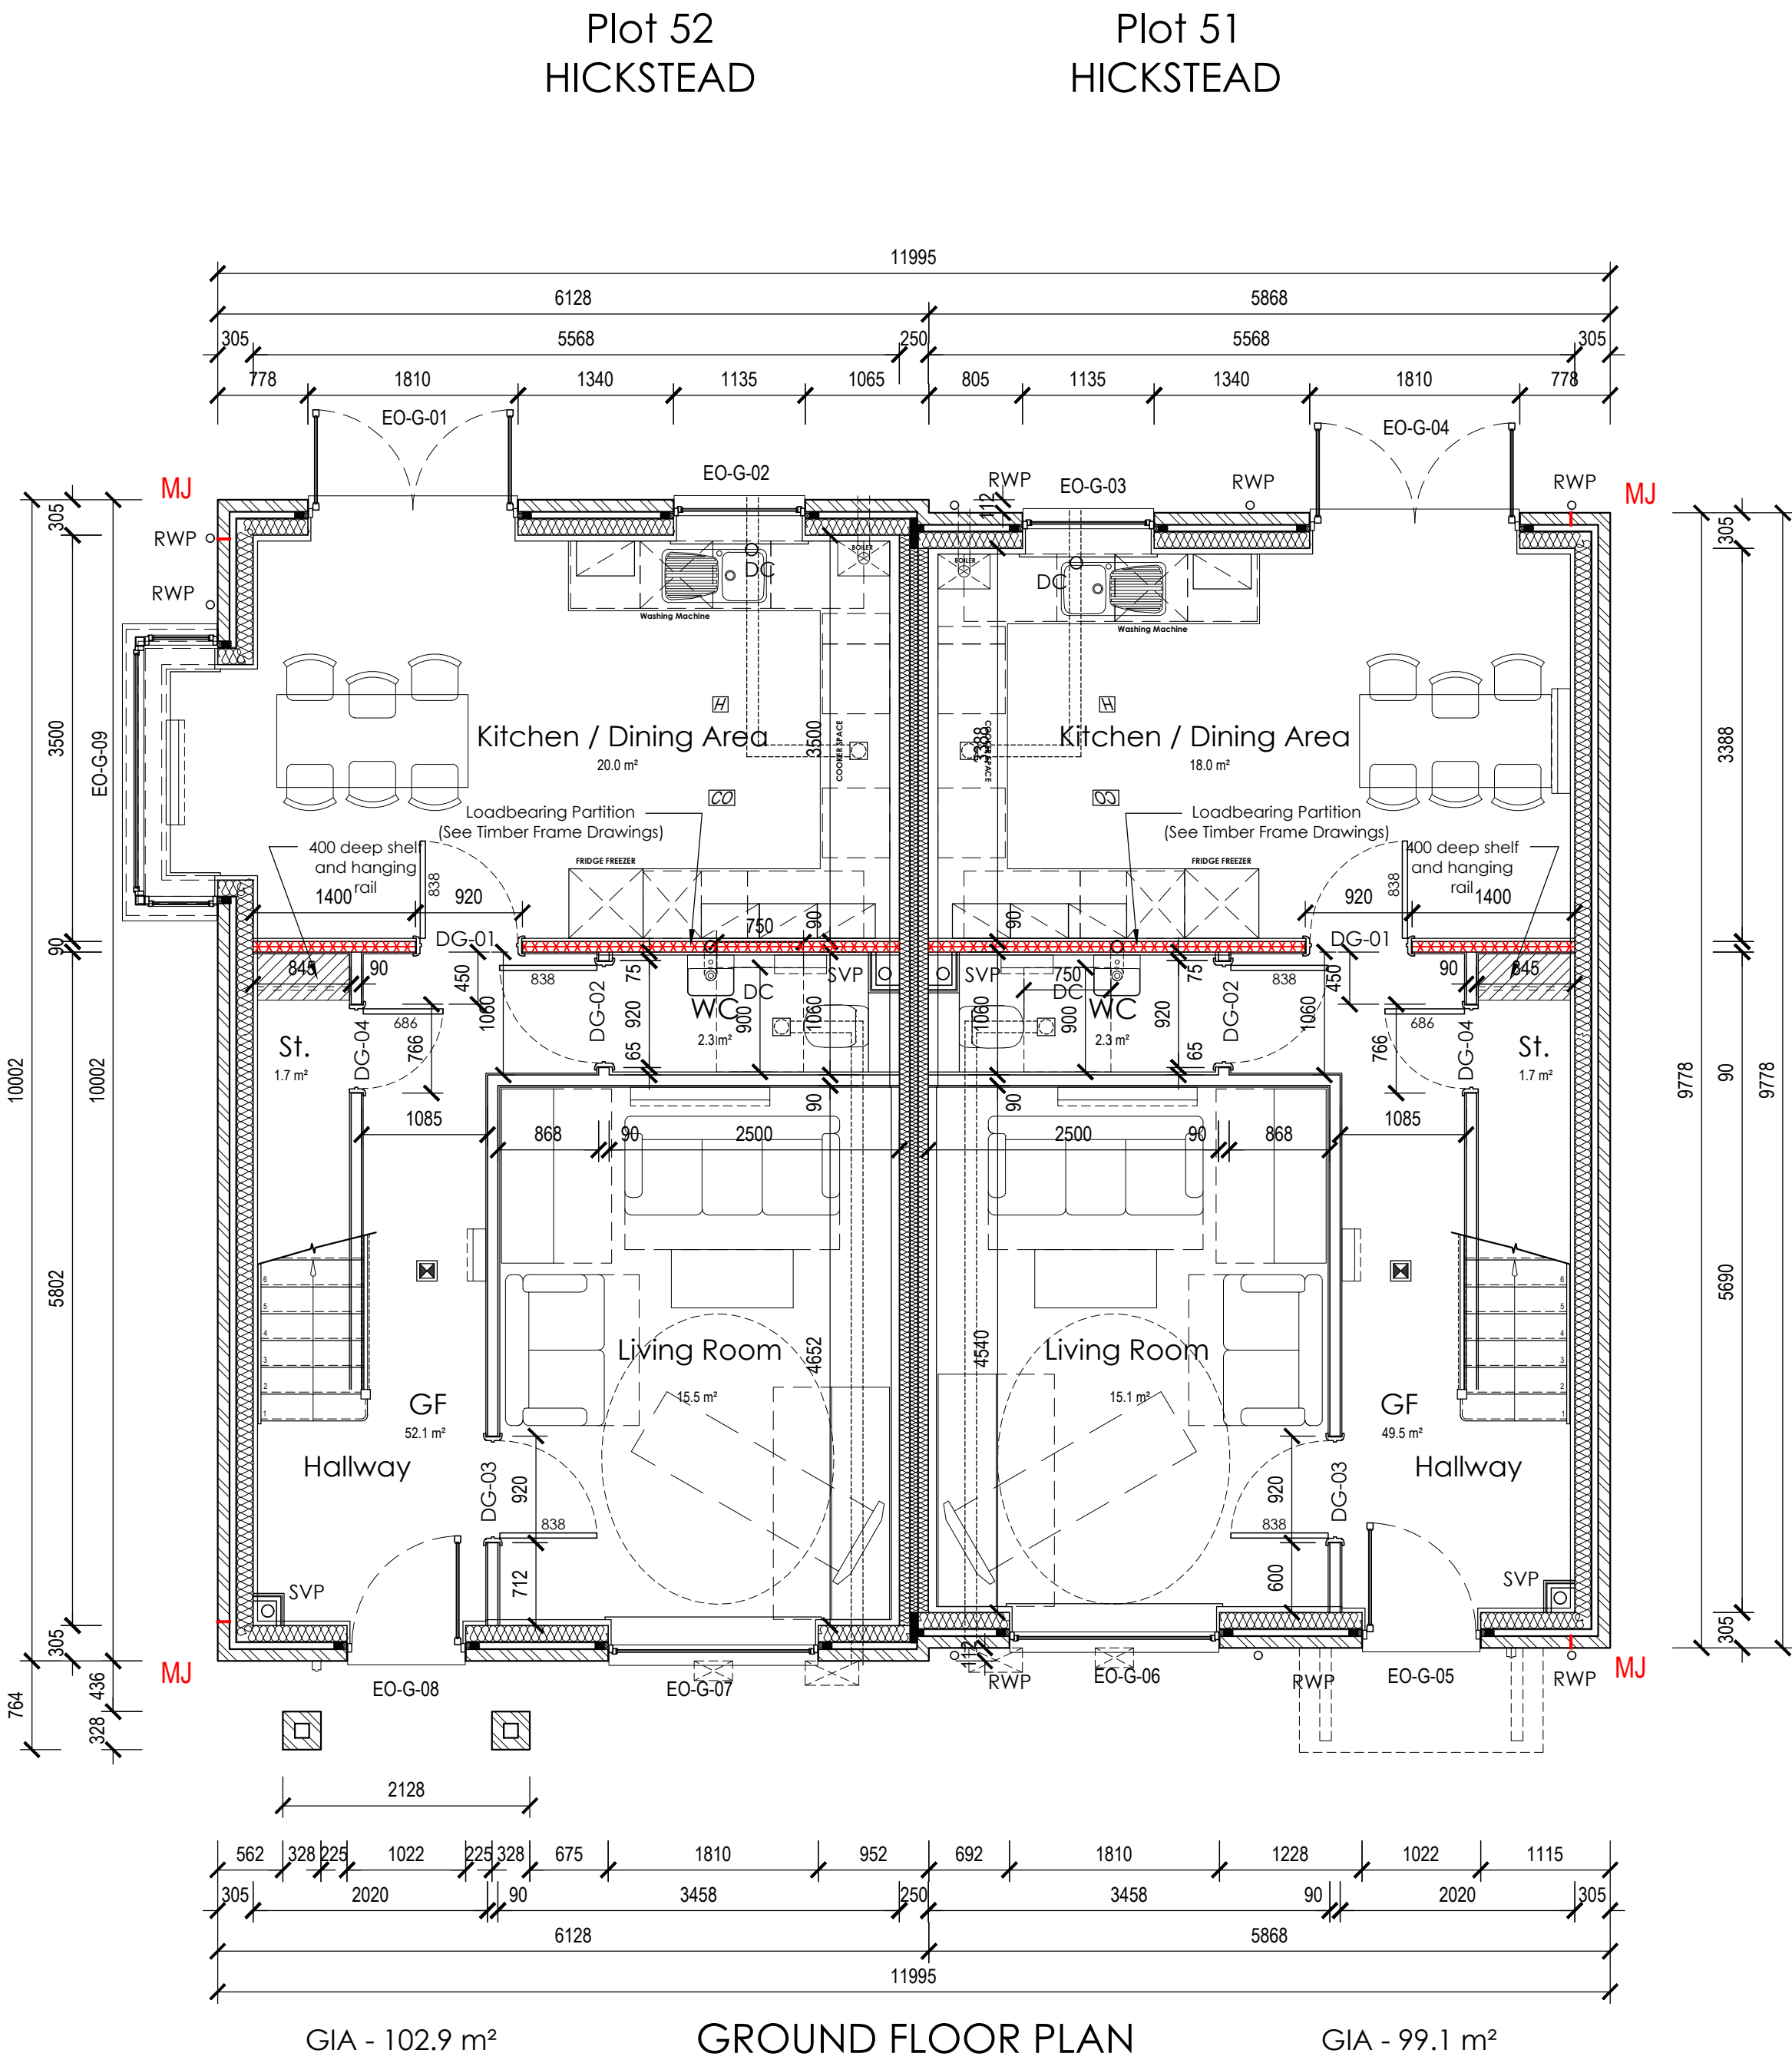

LEGEND	
	Loadbearing Wall (Please refer to Structural Engineers details)
	Loft Access Hatch
	Smoke Detector
	Indicative Radiator Positions
	Indicative Location of Movement Joint

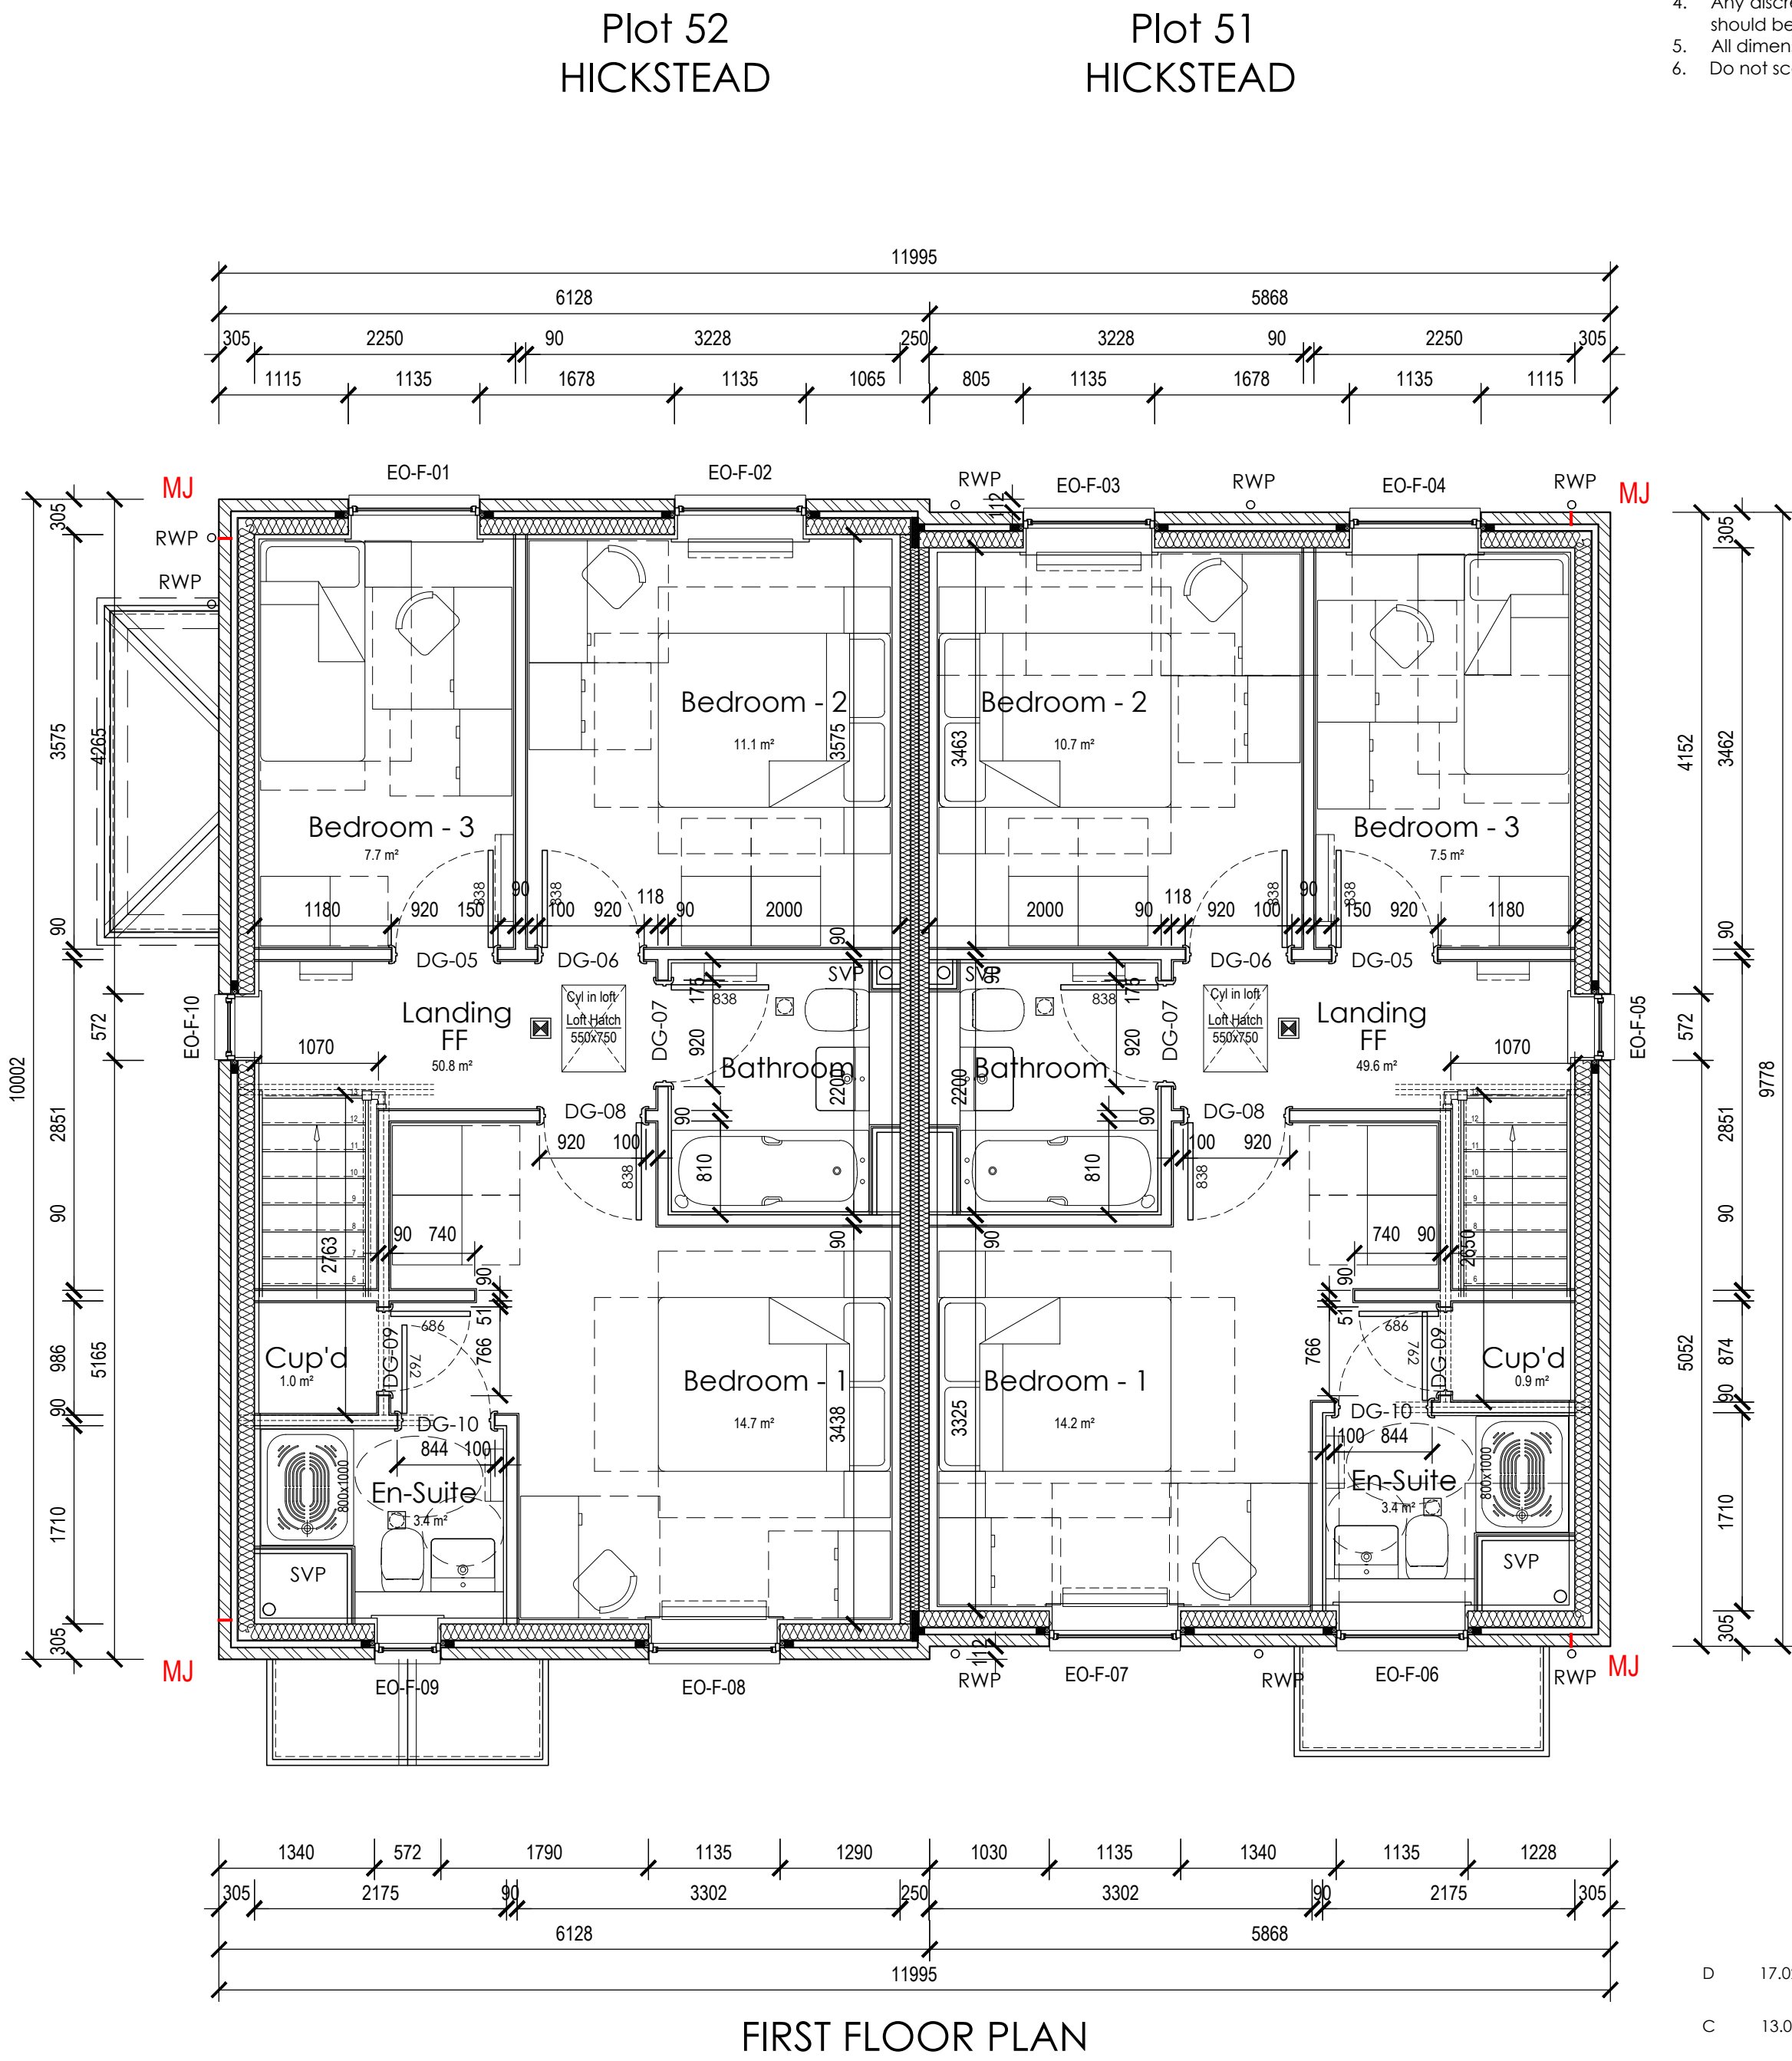

D	17.02.22	EO-F-06 velux to en-suite replaced with dormer window	SS	DK
C	13.02.21	Sanitaryware updated and layout adjusted as requested by client.	RL	SS
B	09.03.20	Further minor layout updates undertaken to reflect clients comments.	SS	DRK
A	09.12.19	First issue	SS	DRK
REV	DATE	DESCRIPTION	REV BY	CKD BY
CLIENT				

DREW SMITH GROUP



PROJECT
SUMMER FIELDS
Summer Lane, Pagham,
West Sussex

DRAWING TITLE
HICKSTEAD - Plot-51-52
Ground / First Floor Plans

DRAWING STATUS	SCALE
PRELIMINARY ISSUE	1:50 @ A1
PROJECT NO. DRAWING NO.	REVISION DRAWN BY
1177-WD-262	D SS