
 


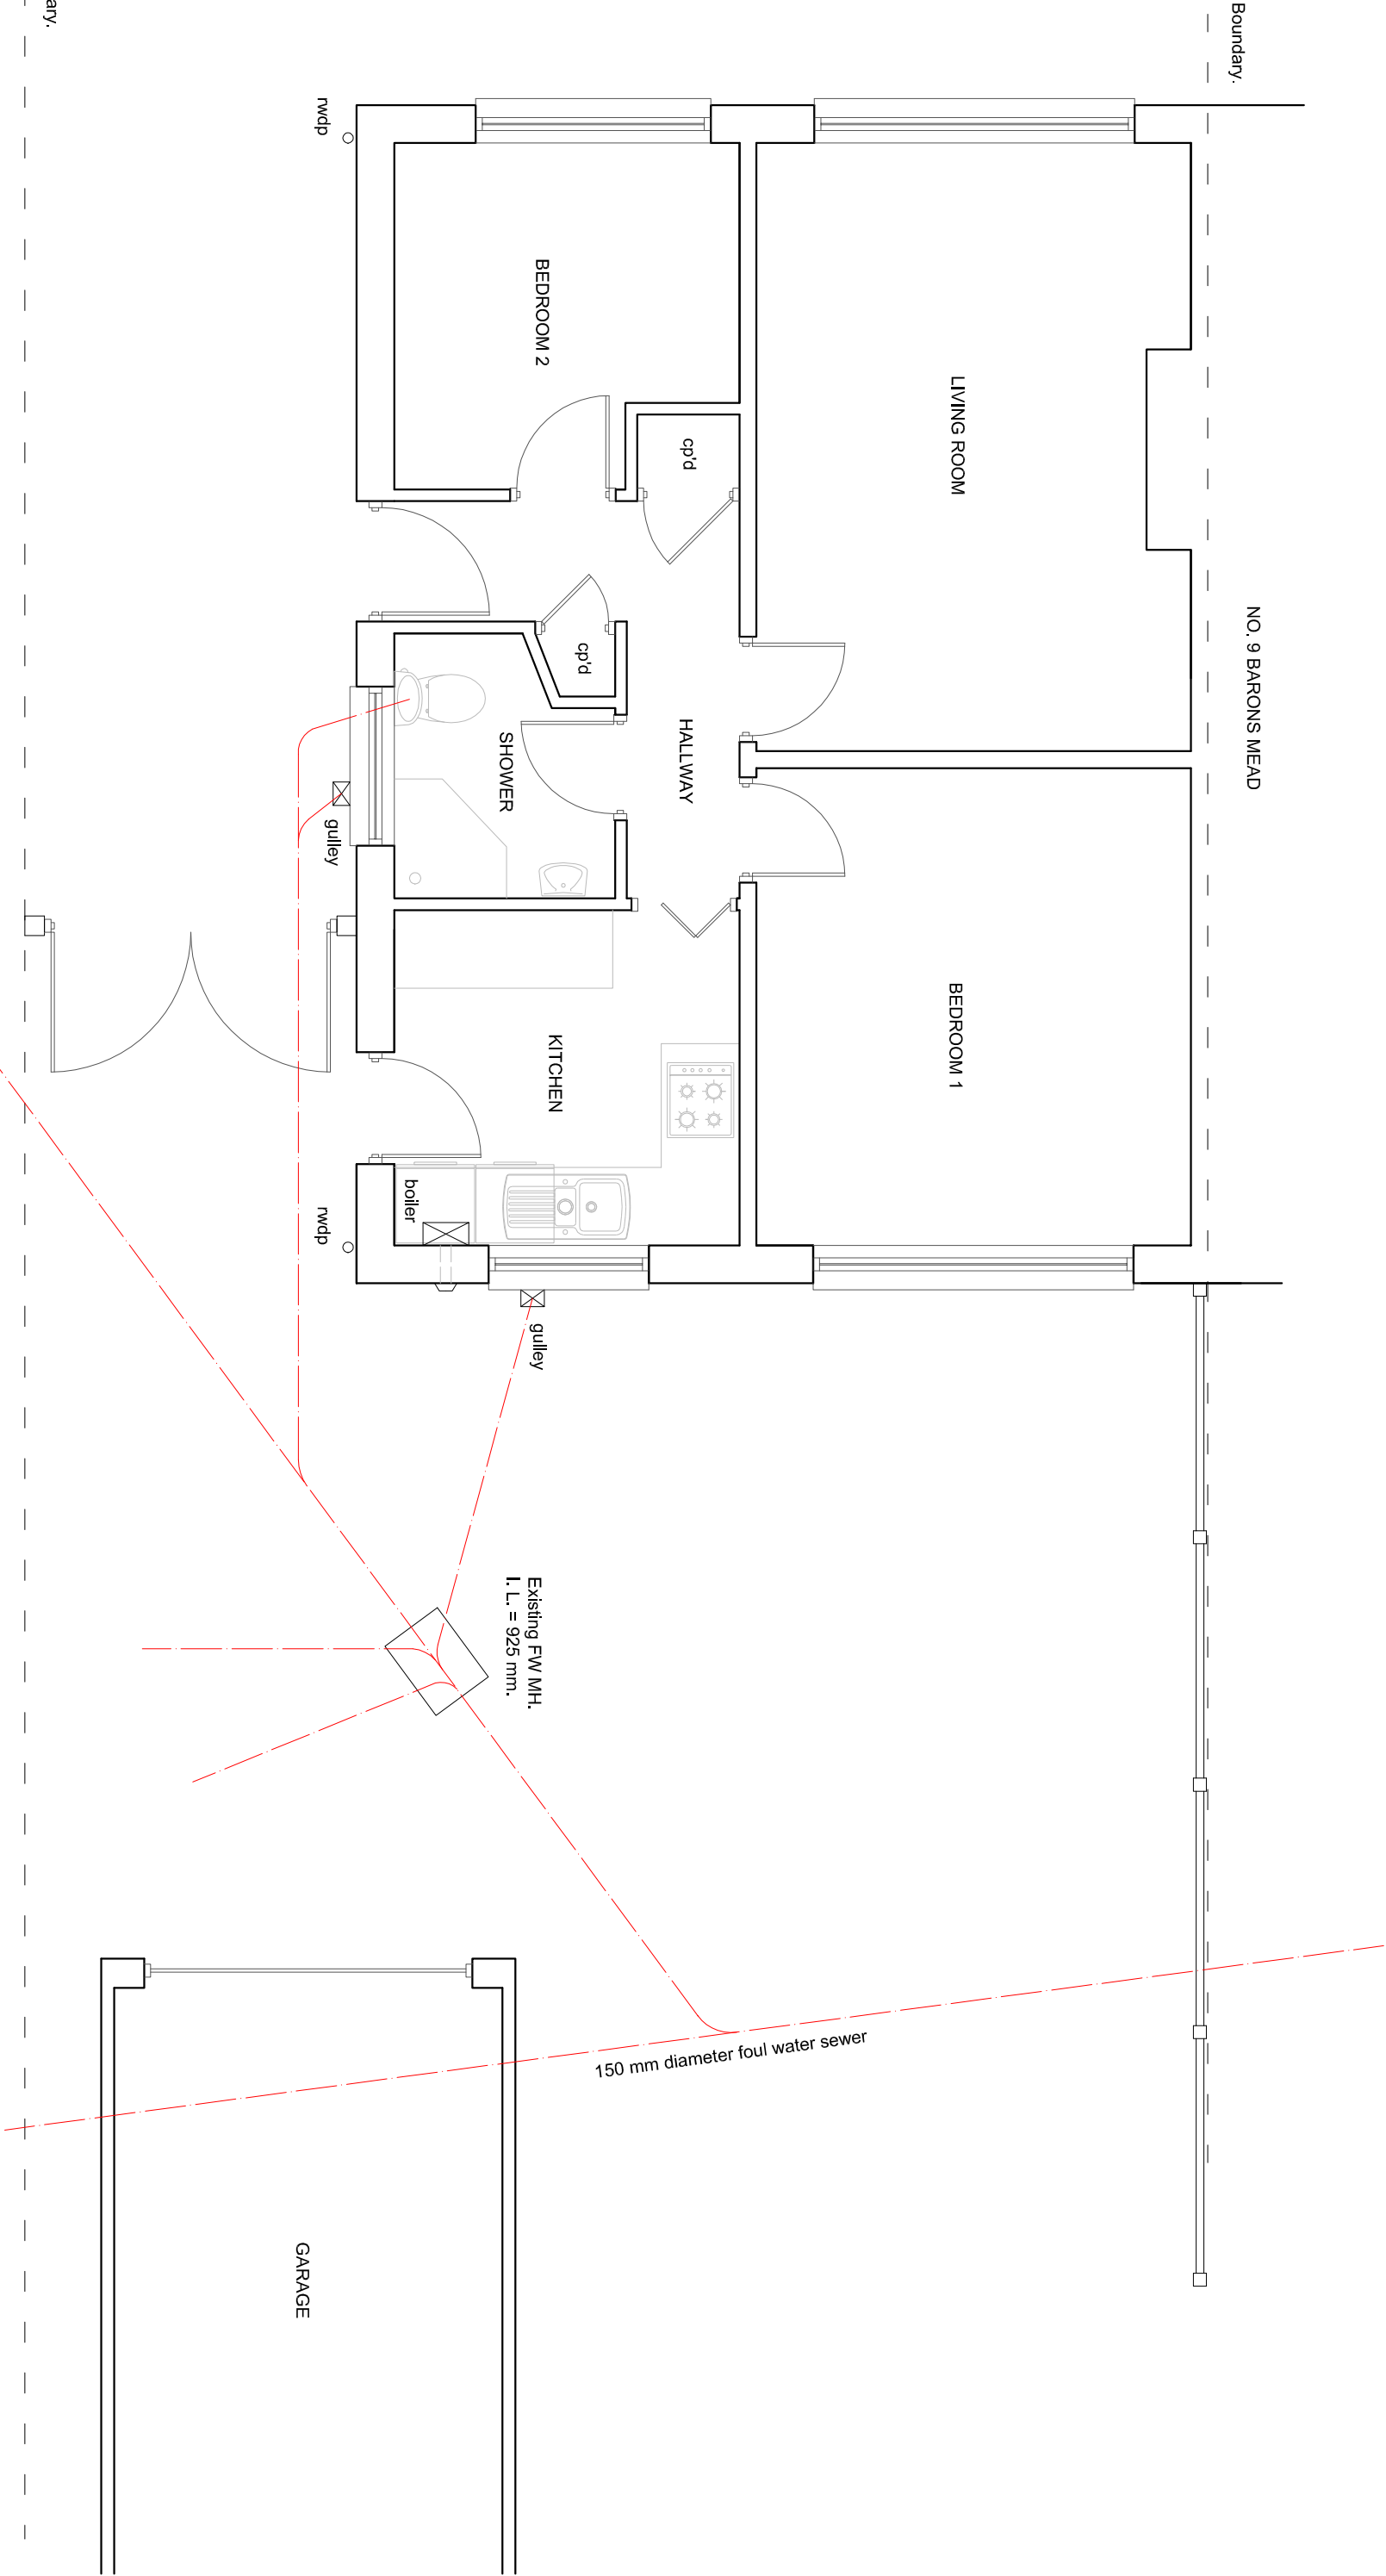

The plotted foul and surface water drainage layouts are derived from limited inspection and will need to be investigated on site and agreed with Building Control and Southern Water Services if necessary.



EXISTING GROUND FLOOR PLAN

Scale 1:50 on A3

SUSSEX BUILDING CONSULTANCY LIMITED

11 BARONS MEAD, PAGHAM,
BOGNOR REGIS, WEST SUSSEX.

SCALE - 1/50 REV - DATE - 12/05/2026

partner
LABC

3 NORTHCOTE ROAD
BOGNOR REGIS
PO21 5LZ
TEL/FAX - (01243) 861379