
 


SITE LOCATION

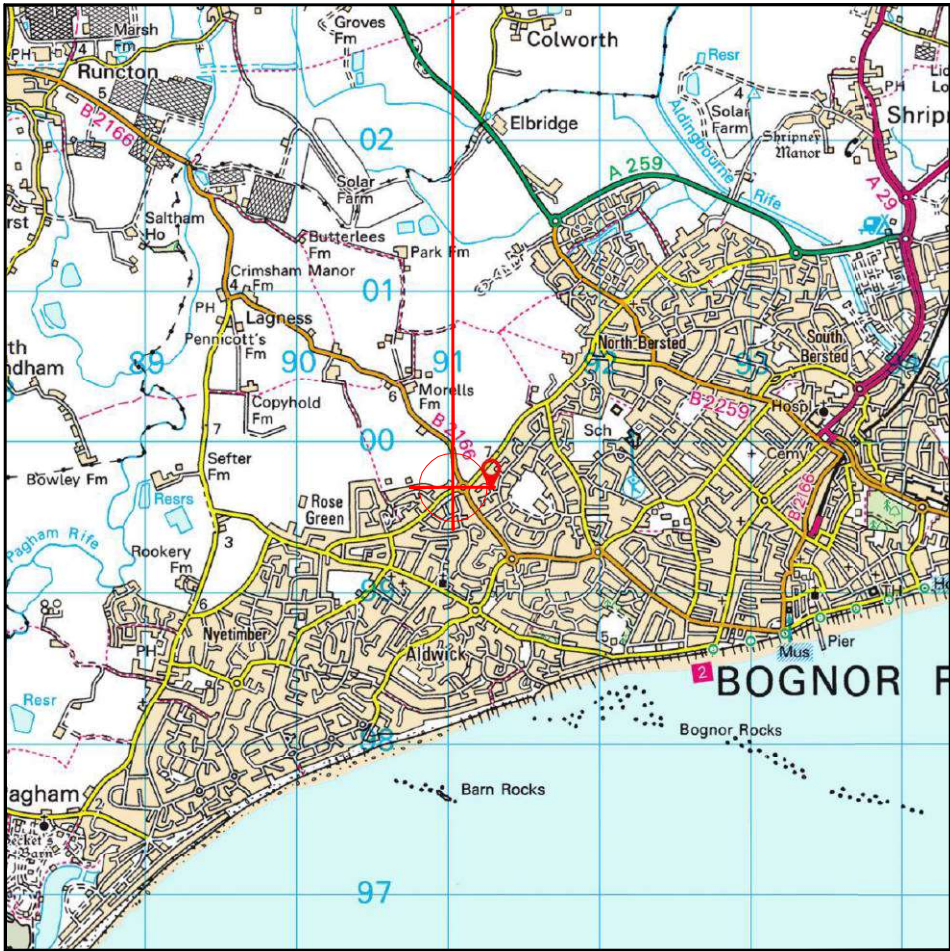


Reproduced by permission of Ordnance Survey on behalf of the Controller of Her Majesty's Stationery Office

SITE AREA PLAN




SITE PHOTOGRAPH

<https://www.google.com/maps/@50.7899038,-0.7081509,3a,75y,273.5h,74.77t/data=!3m6!1e1!3m4!1shgvAtCcBaeJaEQQpSbiWyQ!2e0!7i113312!8i6656>

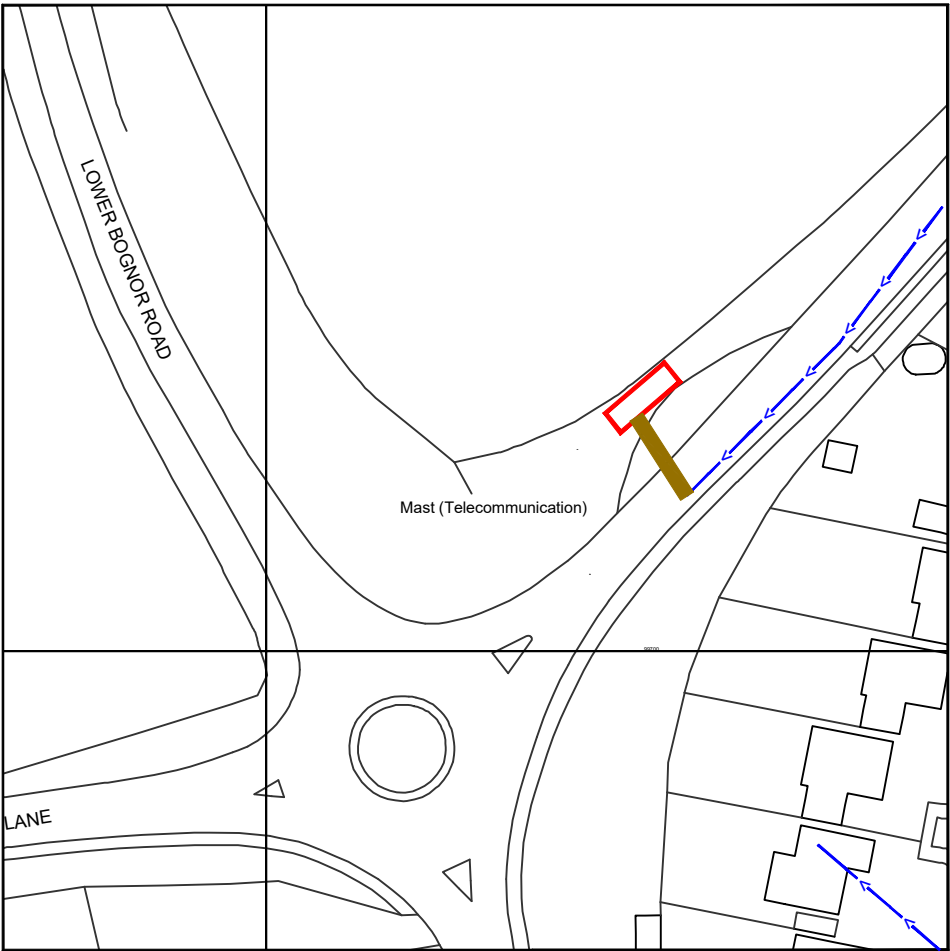

Reproduced by permission of Ordnance Survey on behalf of the Controller of Her Majesty's Stationery Office

 SITE LOCATION PLAN



GOOGLE MAPS QR CODE

GOOGLE MAPS HYPERLINK

<https://www.google.com/maps/@50.7901831,-0.7083209,102m/data=!3m1!1e3>

GOOGLE MAPS STREETVIEW HYPERLINK

NOTES:

1. ALL DIMENSIONS IN MM UNLESS OTHERWISE NOTED.

DIRECTIONS TO SITE:
HEAD NORTH WEST ON M40.
AT JUNCTION 9 TAKE THE A34/A41 EXIT TO OXFORD/NEWBURY. AT THE
ROUNDBOUT TAKE THE 1ST EXIT ONTO A34. AFTER 5 MILES TAKE THE
A44 EXIT TOWARDS OXFORD. AT THE ROUNDBOUT TAKE THE 2ND EXIT
ONTO WOODSTOCK ROAD/A44. AT THE ROUNDBOUT TAKE THE 2ND EXIT
ONTO ELSFIELD WAY, AFTER 0.4 MILES TURN LEFT. SITE LOCATED ON
RIGHT HAND SDE.



Master:	MBNL / EE / H3G:	Project:	Purpose of Issue:	Issue:
M001	MBNL	H3G UNILATERAL SW	Planning	A
Date:	21/05/2020	Revision / Upgrade Description:		
Drawn:	A.Heaton	First Issue - Site nomination dated: TBC		
Checked:	A.Dobson			
Approved:	A.Dobson			



Hutchison 3G UK Limited
Star House, 20 Grenfell Road
Maidenhead, SL6 1EH
Tel: 01628 786 900
Fax: 01628 786 901



Hatfield Business Park
Hatfield
Hertfordshire
AL10 9BW
Tel: 01707 315000
Fax: 01707 319001



Mobile Broadband Network Limited
Sixth Floor, Thames Tower, Station Road, Reading, RG1 1LX

Design Consultant & Principal Contractor:



Unit E, Madison Place, Northampton Road,
Manchester, M40 5AG
Tel: 0161 785 4500 Fax: 0161 785 4501
Web: www.clarke-telecom.com

Site Name: CHALCRAFT LANE

Site ID: 1107443

Address:
CHALCRAFT LANE / LOWER BOGNOR ROAD
LOWER BOGNOR ROAD
BOGNOR REGIS
WEST SUSSEX
PO21 5QB


Title: 002 SITE LOCATION PLAN

Project: H3G UNILATERAL SW

Purpose of Issue: PLANNING

EE Cell ID:	MBNL Cell ID:	3UK Cell ID:
25535	ARN046	PO0166

Master Drawing No:	Issue:
1107443_25535_ARN046_PO0166_M002	A

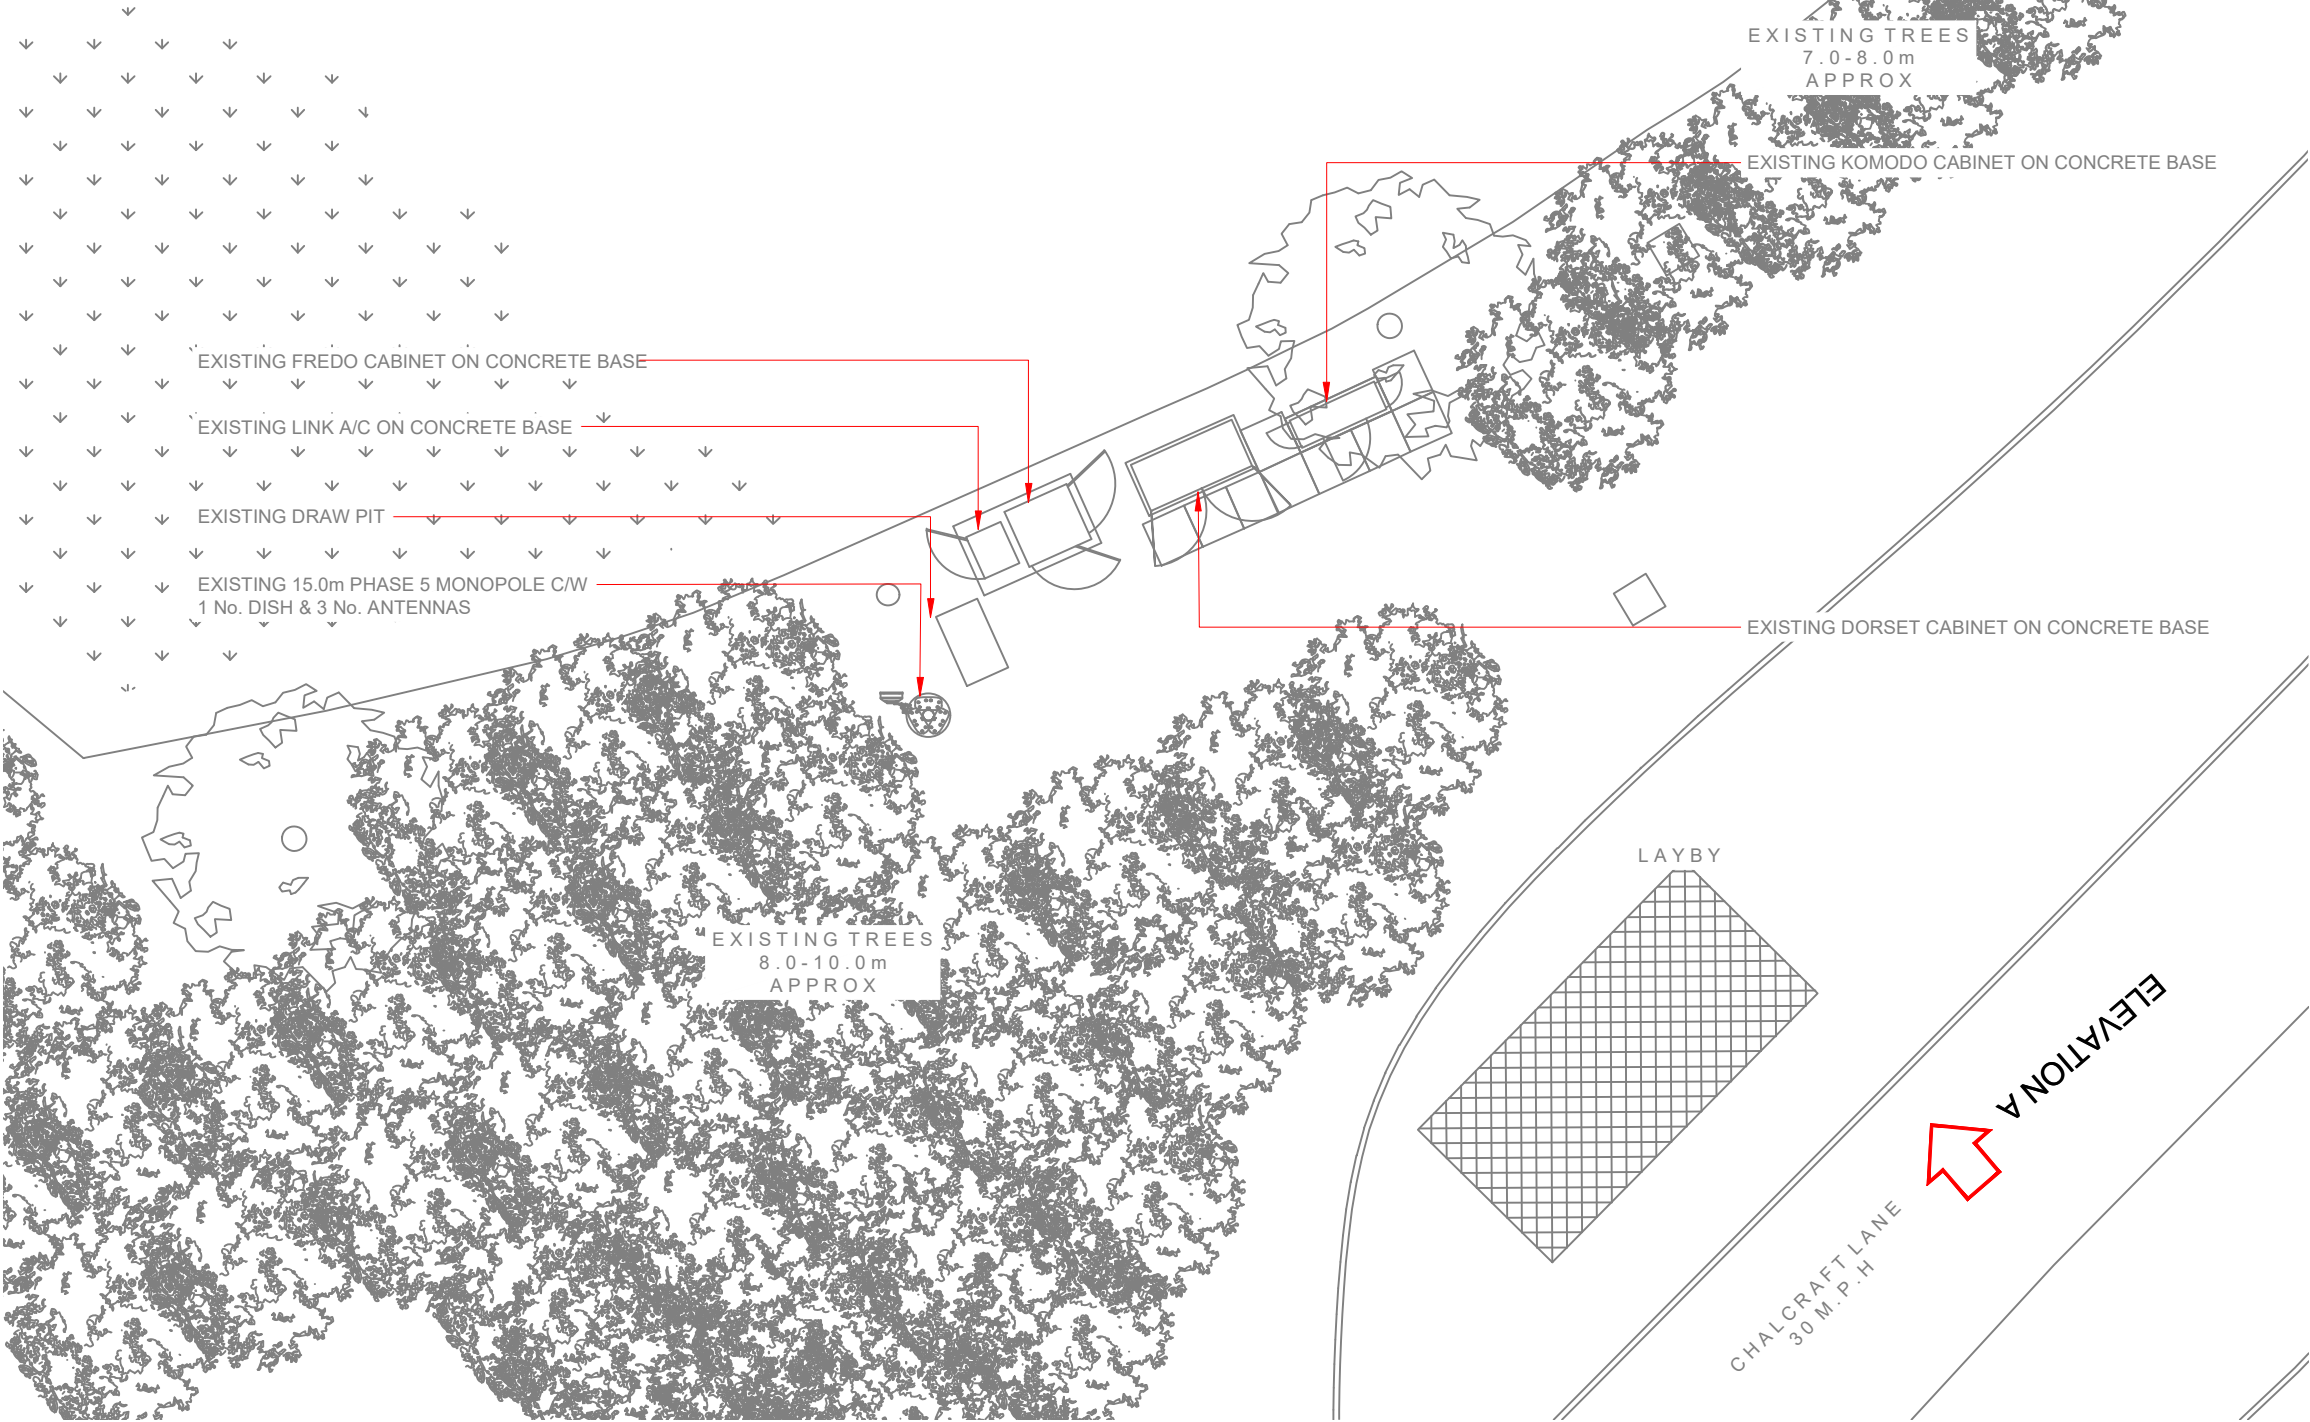

3G / 4G Antenna ID	Existing 3G Bearing
uA1	****
uB1	*****
uC1	*****

NOTES:

1. ALL DIMENSIONS IN MM UNLESS OTHERWISE NOTED.

Master:	MBNL / EE / H3G:	Project:	Purpose of Issue:	Issue:
M001	MBNL	H3G UNILATERAL SW	Planning	A
Date:	21/05/2020	Revision / Upgrade Description:		
Drawn:	A.Heaton	First Issue - Site nomination dated: TBC		
Checked:	A.Dobson			
Approved:	A.Dobson			



Hutchison 3G UK Limited
Star House, 20 Grenfell Road
Maidenhead, SL6 1EH
Tel: 01628 786 000
Fax: 01628 786 001

H3G Base Station Information line:
0845 6043000
Available 8am-8pm Monday to Friday



Hatfield Business Park
Hatfield
Hertfordshire
AL10 9BW

Tel: 01707 315000
Fax: 01707 319001

Mobile Broadband Network Limited
Sixth Floor, Thames Tower, Station Road, Reading, RG1 1LX

Design Consultant & Principal Contractor:

CLARKE
telecom

Unit E, Madison Place, Northampton Road,
Manchester, M40 5AG
Tel: 0161 785 4500 Fax: 0161 785 4501
Web: www.clarke-telecom.com

Site Name: CHALCRAFT LANE

Site ID: 1107443

Address: CHALCRAFT LANE / LOWER BOGNOR ROAD
LOWER BOGNOR ROAD
BOGNOR REGIS
WEST SUSSEX
PO21 5QB

Title: 100 EXISTING SITE PLAN


Project: H3G UNILATERAL SW

Purpose of Issue: PLANNING

EE Cell ID: 25535	MBNL Cell ID: ARN046	3UK Cell ID: PO0166
----------------------	-------------------------	------------------------

Master Drawing No: 1107443_25535_ARN046_PO0166_M002	Issue: A
--	-------------

 EXISTING SITE PLAN



100mm


50mm

10mm

3G / 4G Antenna ID	Existing 3G Bearing
uA1	****
uB1	*****
uC1	*****

NOTES:

1. ALL DIMENSIONS IN MM UNLESS OTHERWISE NOTED.

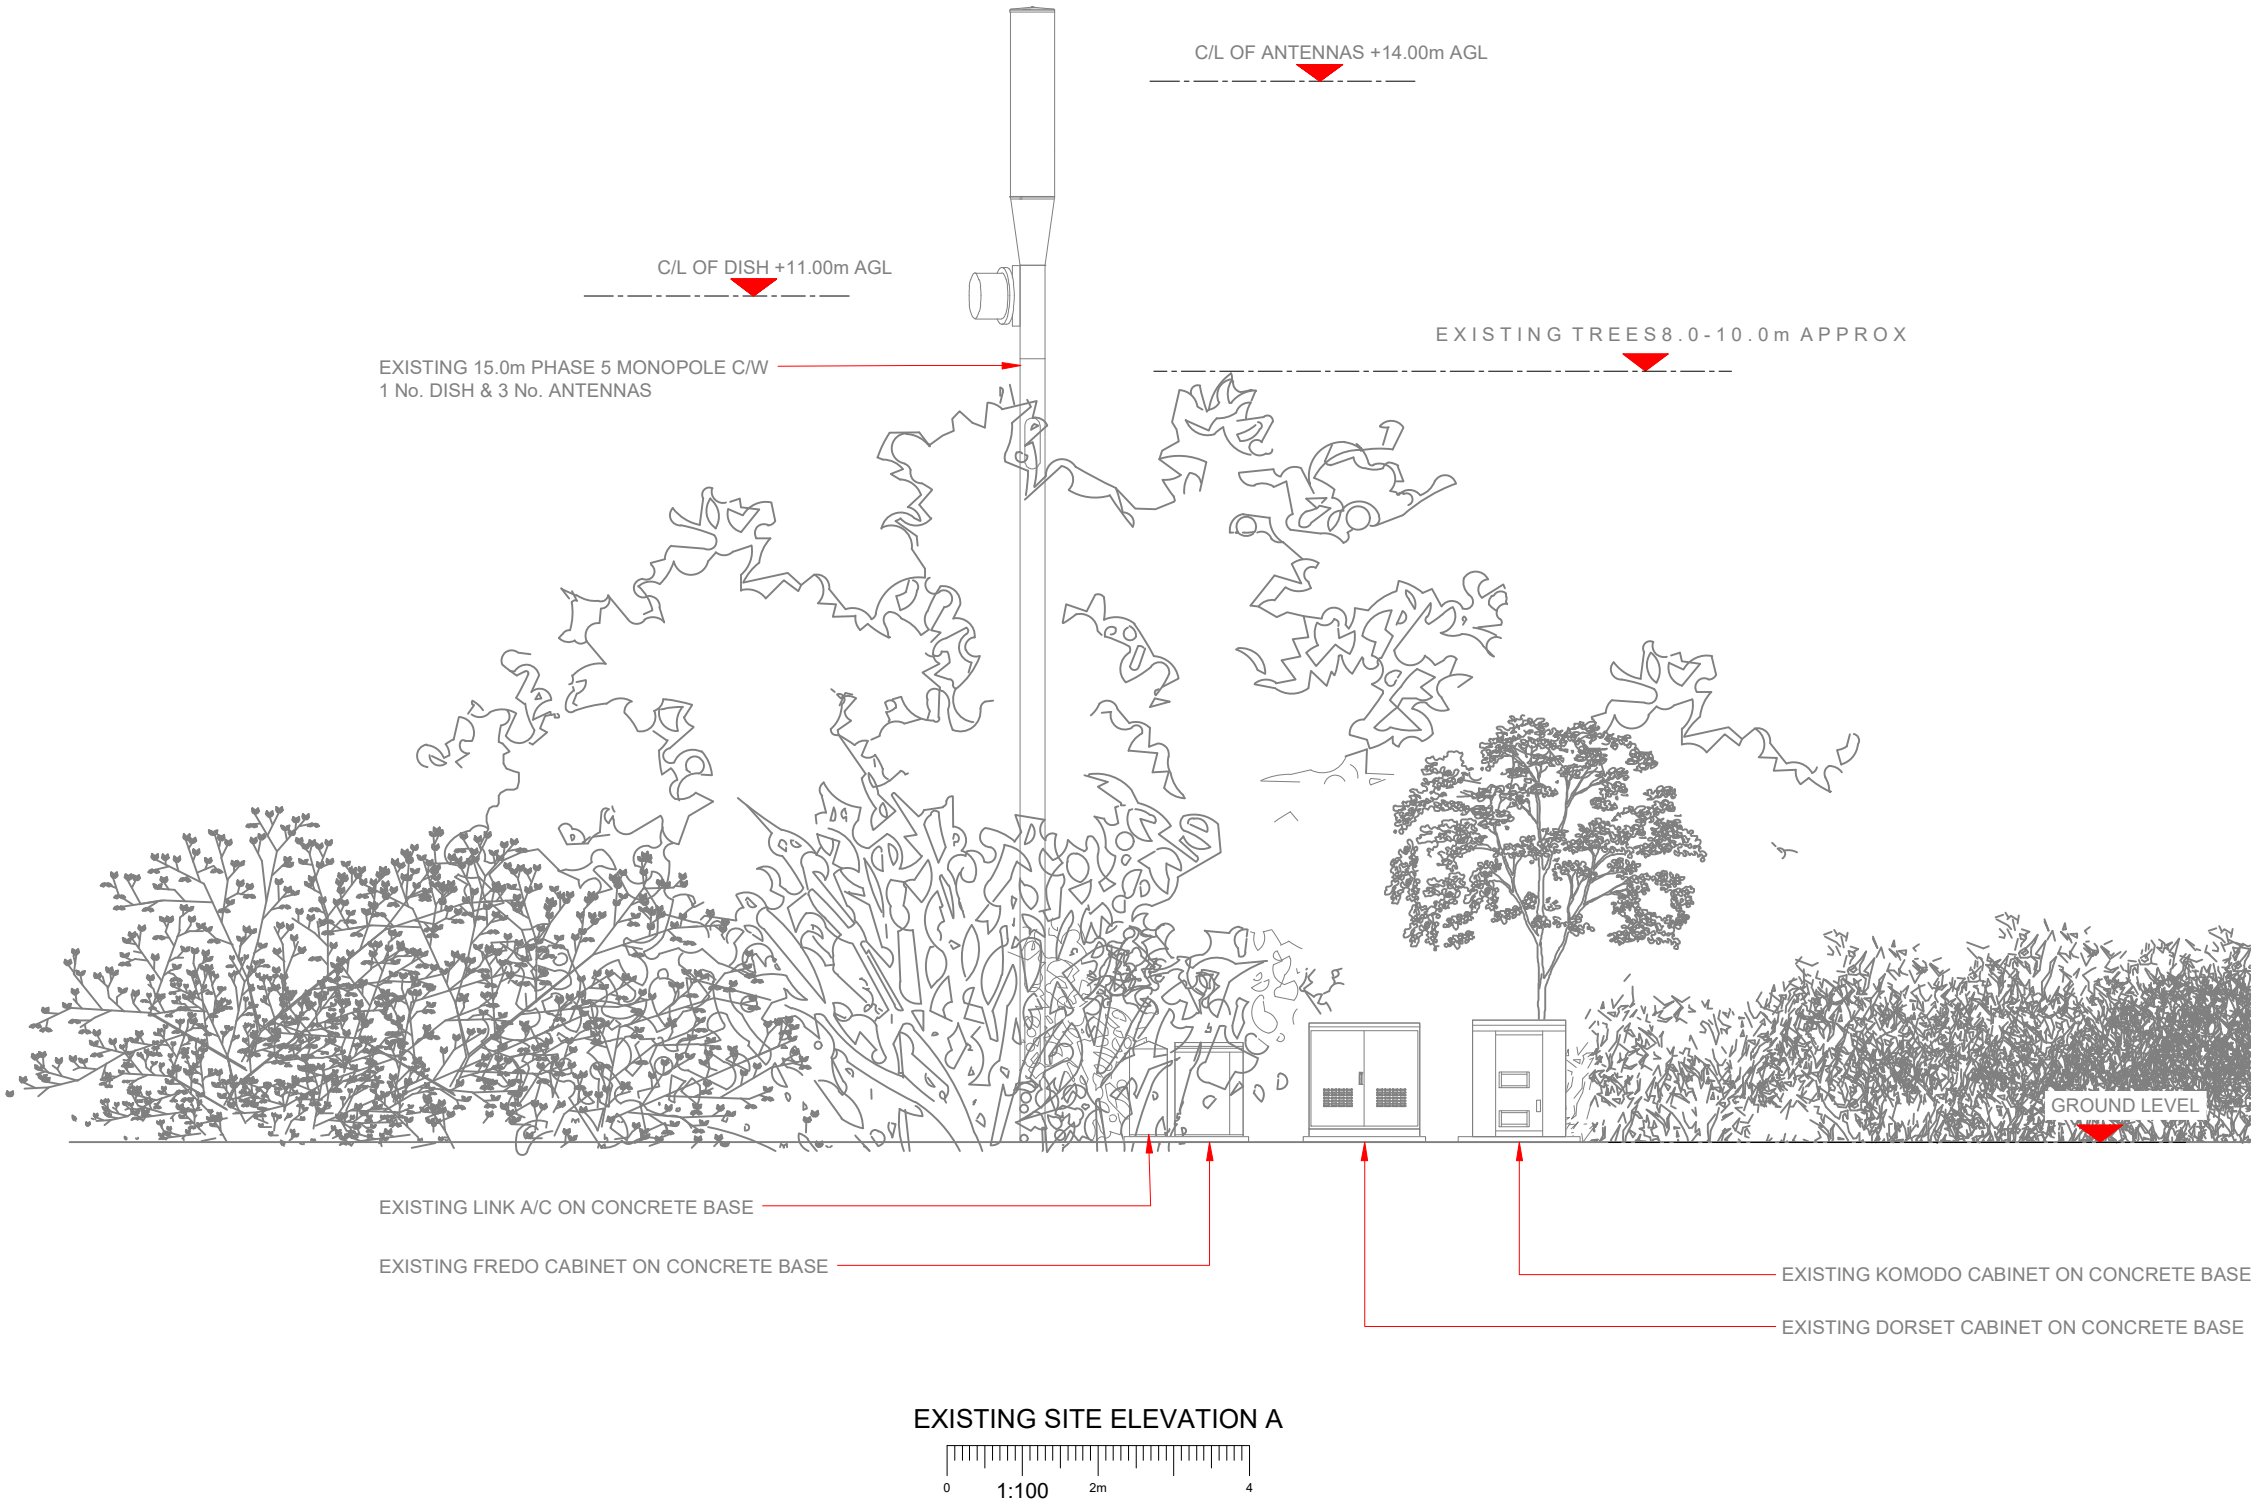

Master:	MBNL / EE / H3G:	Project:	Purpose of Issue:	Issue:
M001	MBNL	H3G UNILATERAL SW	Planning	A
Date:	21/05/2020	Revision / Upgrade Description:		
Drawn:	A.Heaton	First Issue - Site nomination dated: TBC		
Checked:	A.Dobson			
Approved:	A.Dobson			

Hutchison 3G UK Limited
Star House, 20 Grenfell Road
Maidenhead, SL6 1EH
Tel: 01628 785 000
Fax: 01628 785 001

H3G Base Station Information line:
0845 6043000
Available 8am-8pm Monday to Friday

Hatfield Business Park
Hatfield
Hertfordshire
AL10 9BW

Tel: 01707 315000
Fax: 01707 319001

MBNL Mobile Broadband Network Limited
Sixth Floor, Thames Tower, Station Road, Reading, RG1 1LX

Design Consultant & Principal Contractor:

CLARKE
telecom

Unit E, Madison Place, Northampton Road,
Manchester, M40 5AG
Tel: 0161 785 4500 Fax: 0161 785 4501
Web: www.clarke-telecom.com

Site Name: **CHALCRAFT LANE**

Site ID: **1107443**

Address: **CHALCRAFT LANE / LOWER BOGNOR ROAD
LOWER BOGNOR ROAD
BOGNOR REGIS
WEST SUSSEX
PO21 5QB**


Title: **150 EXISTING ELEVATIONS**

Project: **H3G UNILATERAL SW**

Purpose of Issue: **PLANNING**

EE Cell ID: 25535	MBNL Cell ID: ARN046	3UK Cell ID: PO0166
-----------------------------	--------------------------------	-------------------------------

Master Drawing No: 1107443_25535_ARN046_PO0166_M002	Issue: A
---	--------------------

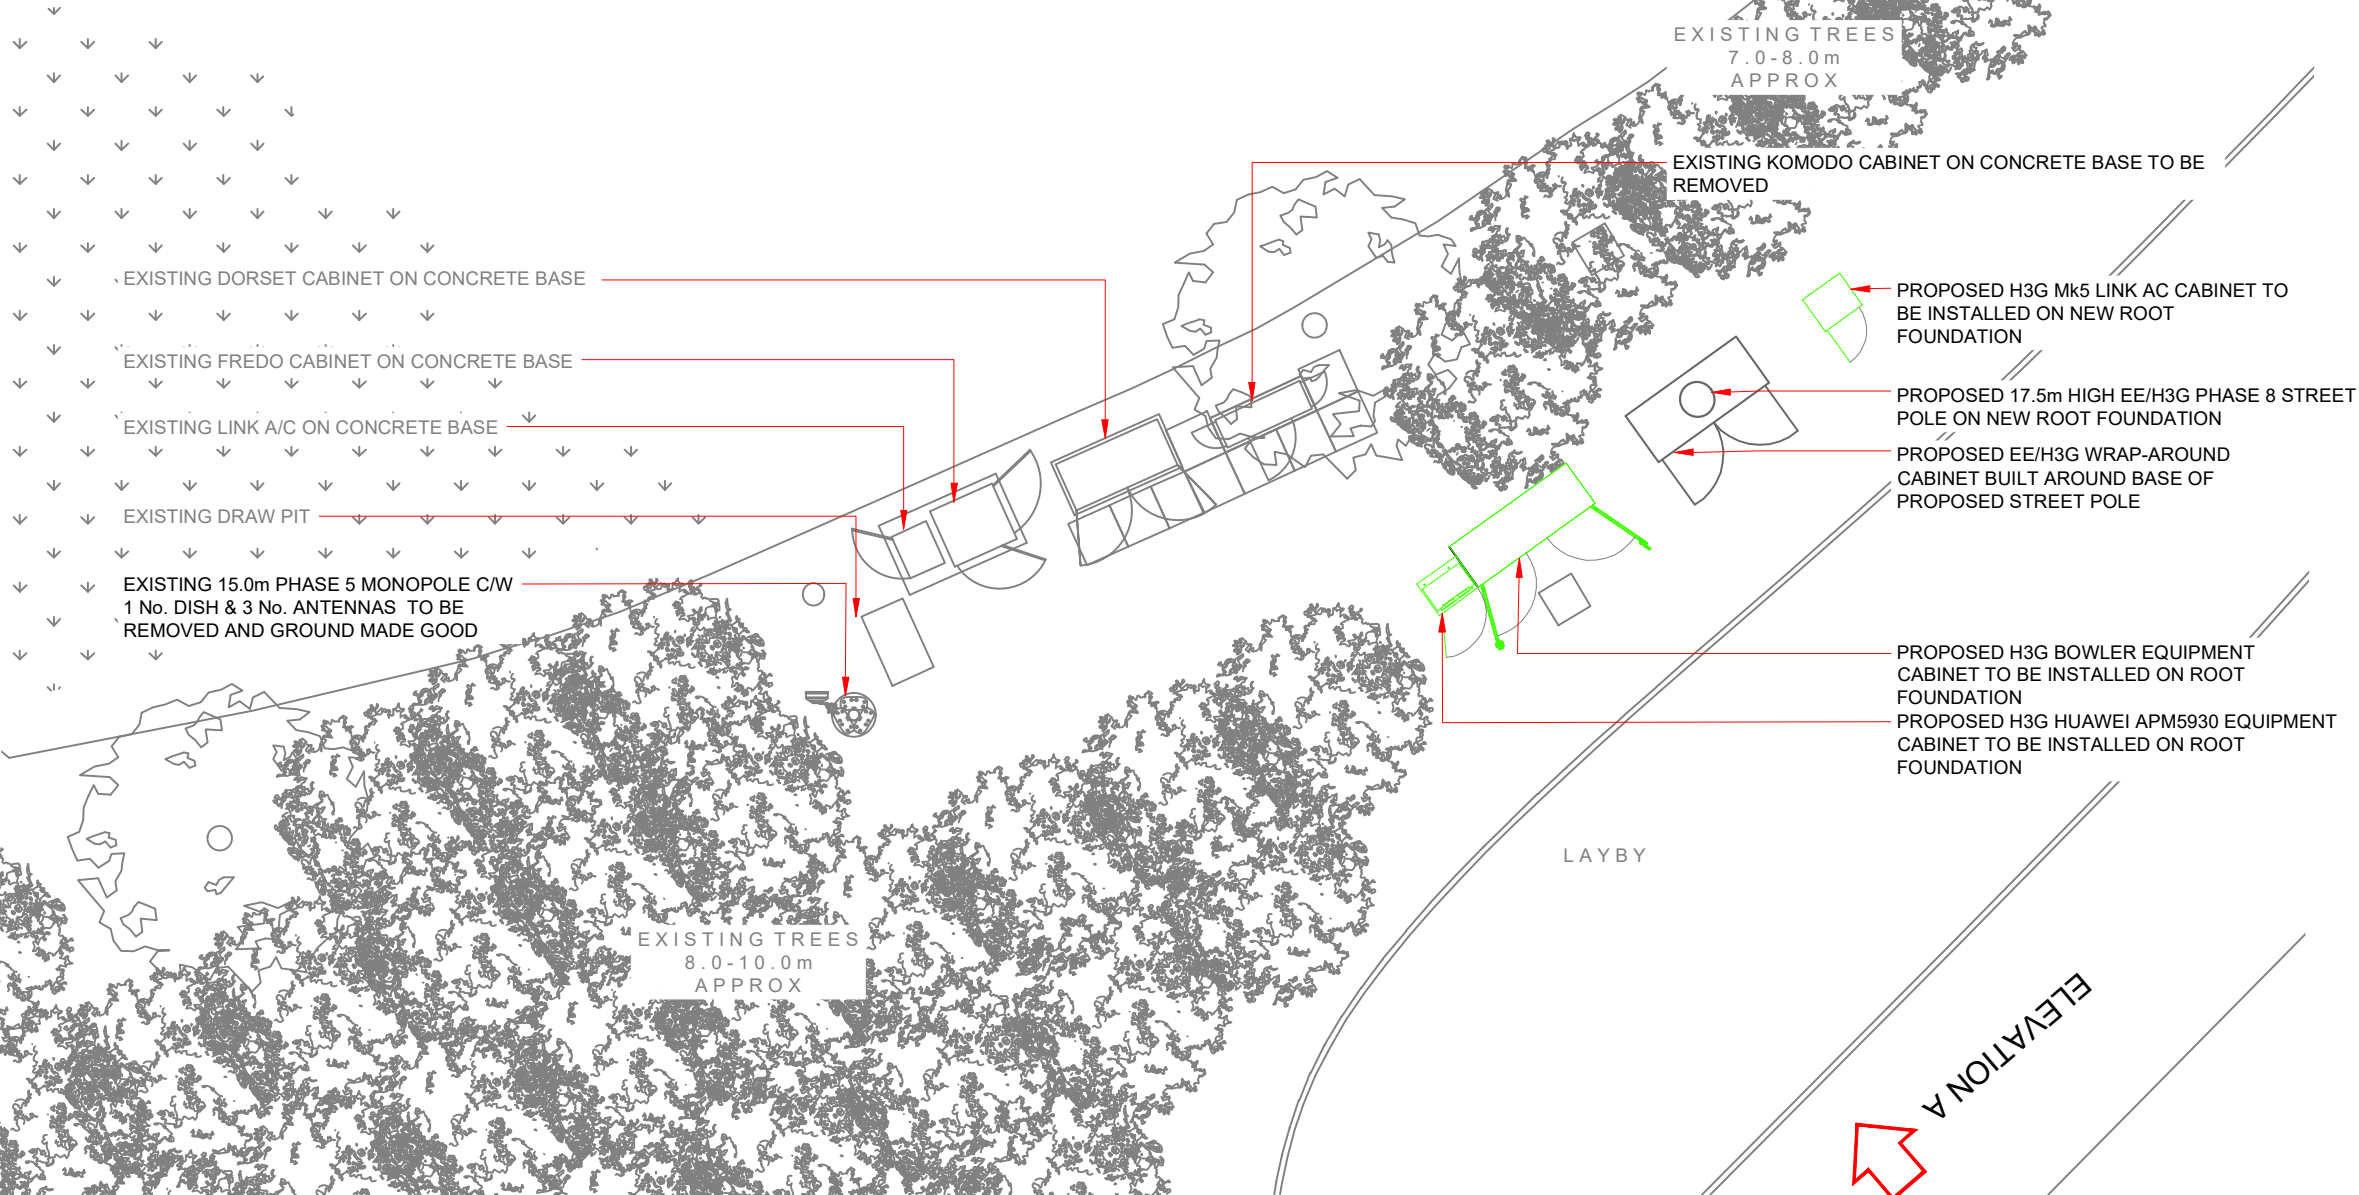

MAXIMUM CONFIGURATION SITE PLAN



Antenna Aperture ID	Proposed 4G/5G Bearing	Operator: Shared/ EE/H3G
A1		H3G
B1		EE/H3G
C1		H3G
A2		EE/H3G
B2		H3G
C2		EE/H3G

NOTES:
1. ALL DIMENSIONS IN MM UNLESS OTHERWISE NOTED.

Master:	MBNL / EE / H3G:	Project:	Purpose of Issue:	Issue:
M001	MBNL	H3G UNILATERAL SW	Planning	A
Date:	21/05/2020	Revision / Upgrade Description:		
Drawn:	A.Heaton	First Issue - Site nomination dated: TBC		
Checked:	A.Dobson			
Approved:	A.Dobson			



Hutchison 3G UK Limited
Star House, 20 Greenfield Road
Maldenhead, SL8 1EH
Tel: 01628 785 000
Fax: 01628 785 001
H3G Base Station Information line:
0845 6043000
Available 8am-8pm Monday to Friday



Hatfield Business Park
Hatfield
Hertfordshire
AL10 9BW
Tel: 01707 315000
Fax: 01707 319001



Mobile Broadband Network Limited
Sixth Floor, Thames Tower, Station Road, Reading, RG1 1LX

Design Consultant & Principal Contractor:

CLARKE telecom

Unit E, Madison Place, Northampton Road,
Manchester, M40 5AG
Tel: 0161 785 4500 Fax: 0161 785 4501
Web: www.clarke-telecom.com

Site Name: CHALCRAFT LANE

Site ID: 1107443

Address: CHALCRAFT LANE / LOWER BOGNOR ROAD
LOWER BOGNOR ROAD
BOGNOR REGIS
WEST SUSSEX
PO21 5QB

Title: 215 MAXIMUM CONFIGURATION
SITE PLAN


Project: H3G UNILATERAL SW

Purpose of Issue: PLANNING

EE Cell ID:	MBNL Cell ID:	3UK Cell ID:
25535	ARN046	PO0166

Master Drawing No:	Issue:
1107443_25535_ARN046_PO0166_M002	A

100mm
50mm
10mm

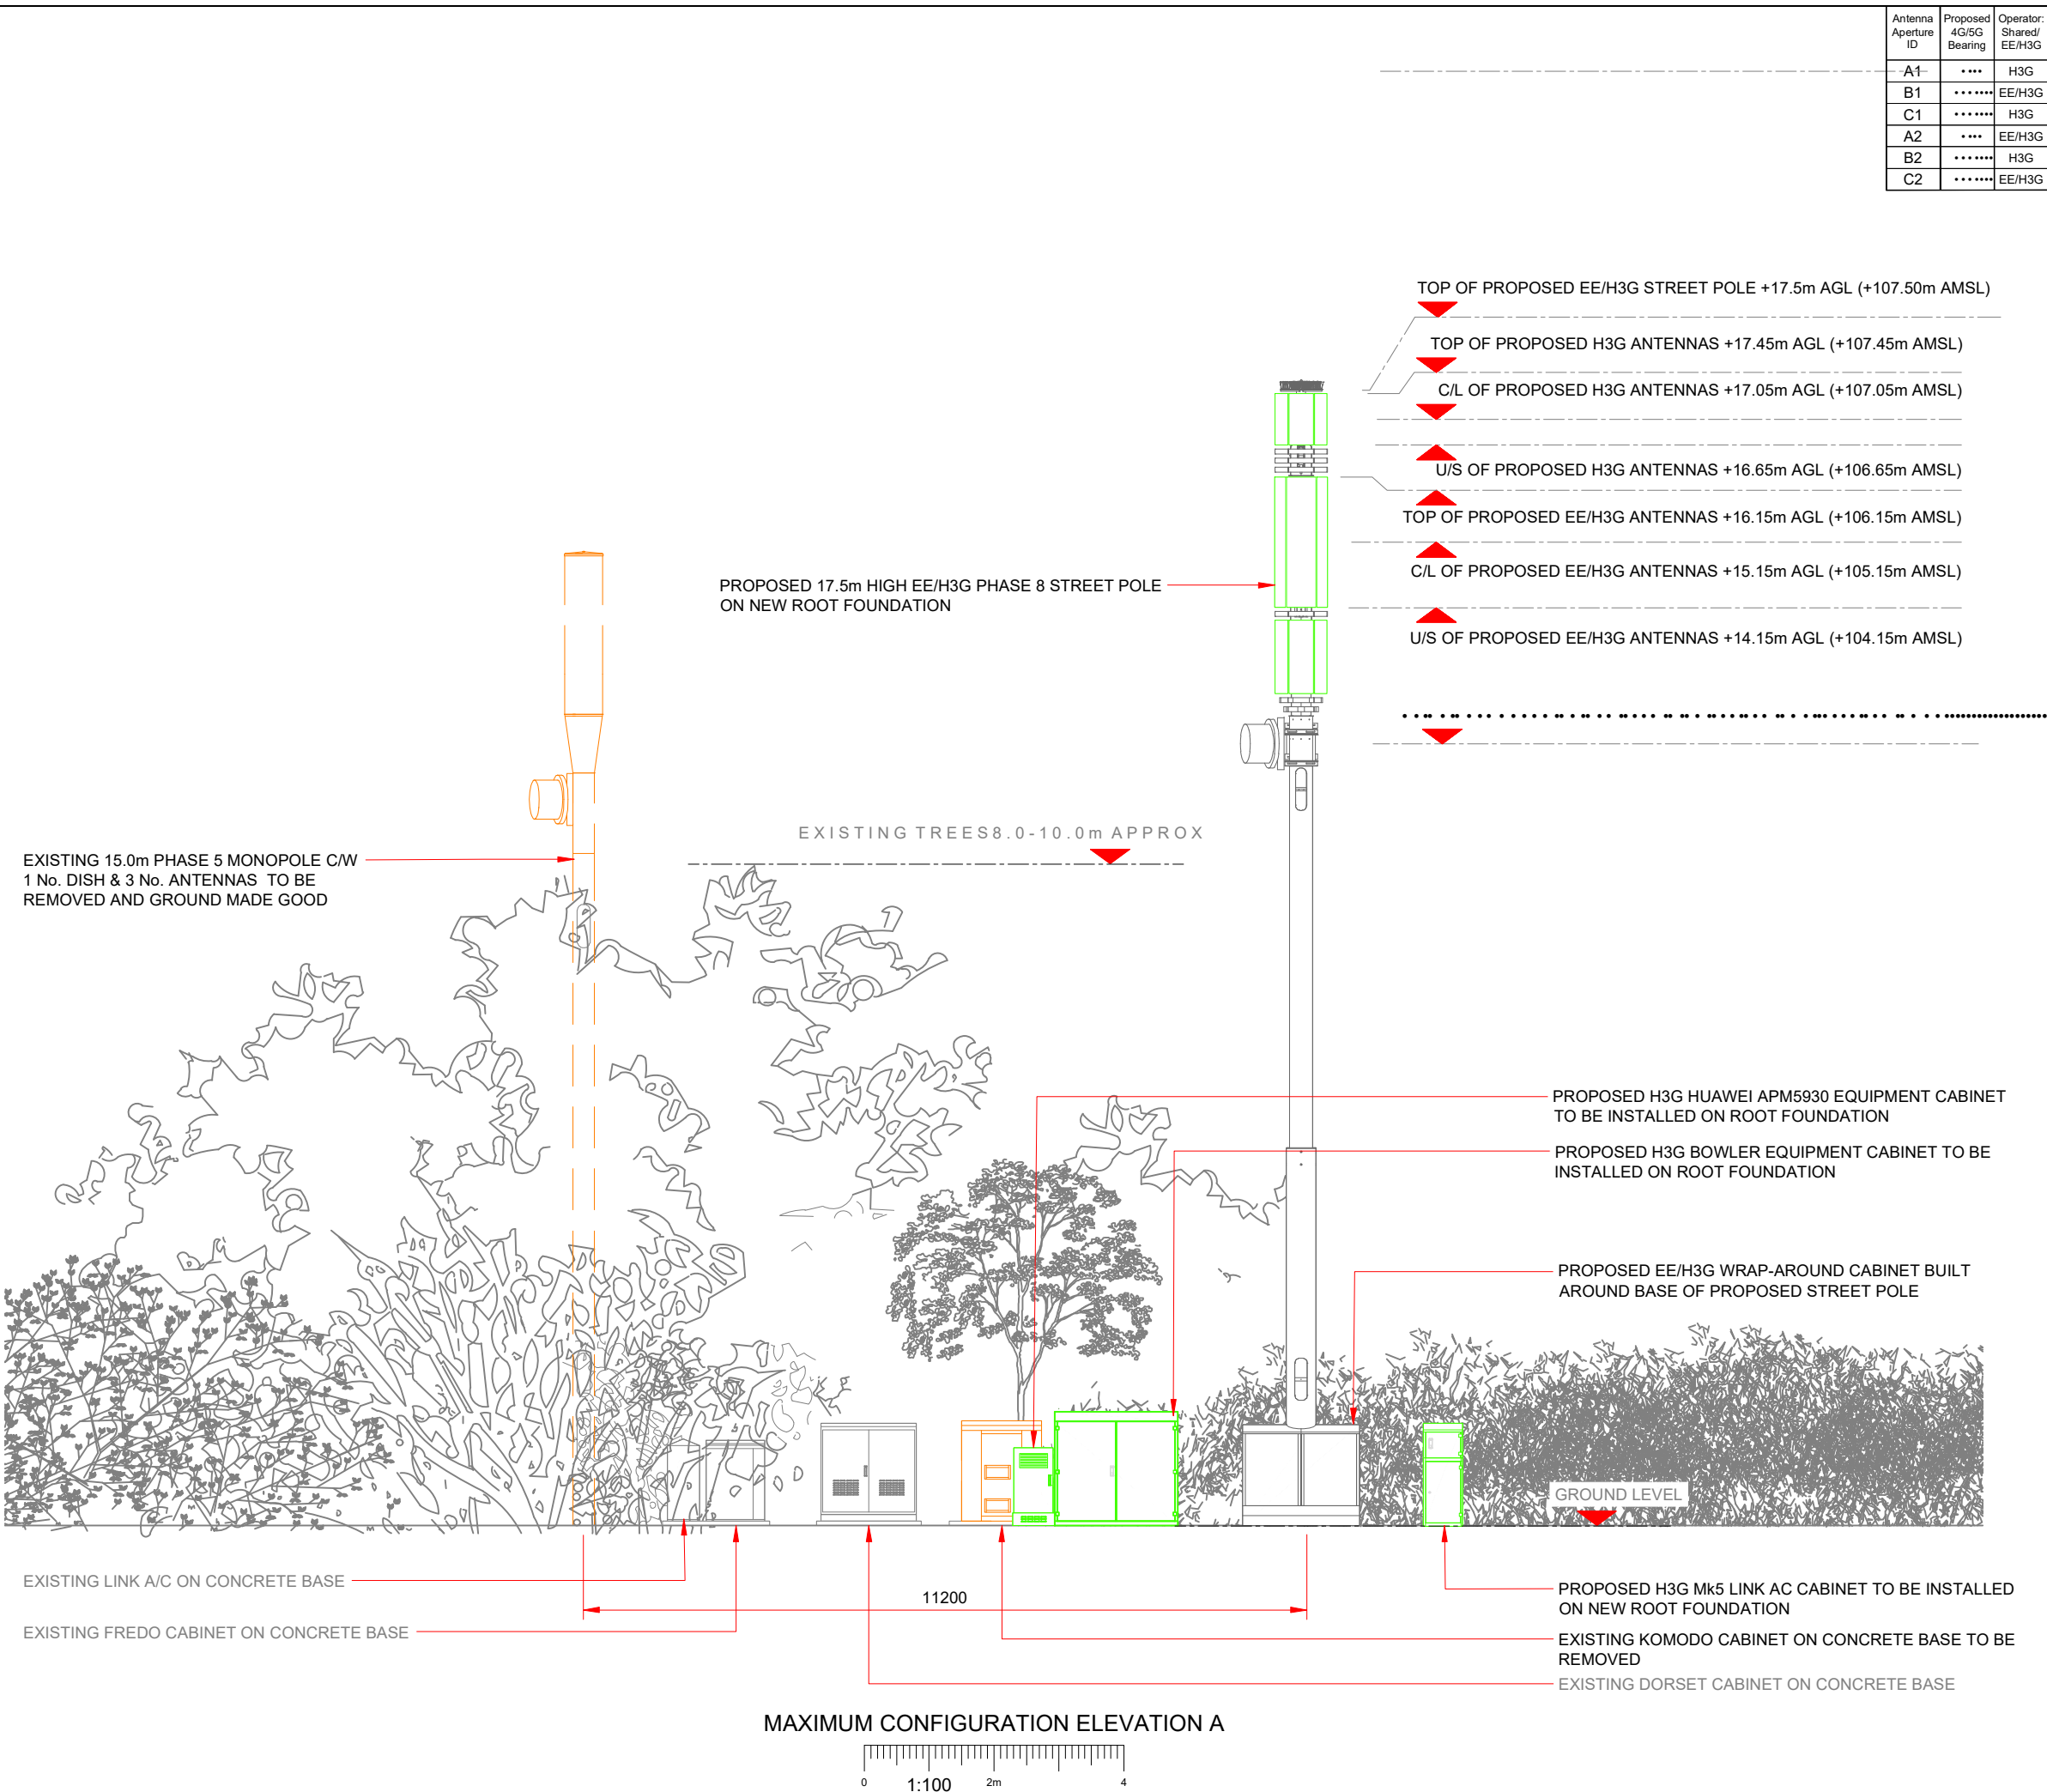

Antenna Aperture ID	Proposed 4G/5G Bearing	Operator: Shared/ EE/H3G
A1		H3G
B1		EE/H3G
C1		H3G
A2		EE/H3G
B2		H3G
C2		EE/H3G

NOTES:
1. ALL DIMENSIONS IN MM UNLESS OTHERWISE NOTED.

Master: M001	MBNL / EE / H3G: MBNL	Project: H3G UNILATERAL SW	Purpose of Issue: Planning	Issue: A
Date: 21/05/2020	Drawn: A.Heaton	Revision / Upgrade Description: First Issue - Site nomination dated: TBC		
Checked: A.Dobson	Approved: A.Dobson			

Hutchison 3G UK Limited
Star House, 20 Grenfell Road
Maidenhead, SL6 1EH
Tel: 01628 785 000
Fax: 01628 785 001

H3G Base Station Information line:
0845 6043000
Available 8am-8pm Monday to Friday

Hatfield Business Park
Hatfield
Hertfordshire
AL10 9BW

Tel: 01707 315000
Fax: 01707 319001

Mobile Broadband Network Limited
Sixth Floor, Thames Tower, Station Road, Reading, RG1 1LX

Design Consultant & Principal Contractor:

Unit E, Madison Place, Northampton Road,
Manchester, M40 5AG
Tel: 0161 785 4500 Fax: 0161 785 4501
Web: www.clarke-telecom.com

Site Name: CHALCRAFT LANE

Site ID: 1107443

Address: CHALCRAFT LANE / LOWER BOGNOR ROAD
LOWER BOGNOR ROAD
BOGNOR REGIS
WEST SUSSEX
PO21 5QB

Title: 265 MAXIMUM CONFIGURATION ELEVATION

Project: H3G UNILATERAL SW

Purpose of Issue: PLANNING

EE Cell ID: 25535	MBNL Cell ID: ARN046	3UK Cell ID: PO0166
-------------------	----------------------	---------------------

Master Drawing No: 1107443_25535_ARN046_PO0166_M002

Issue: A