
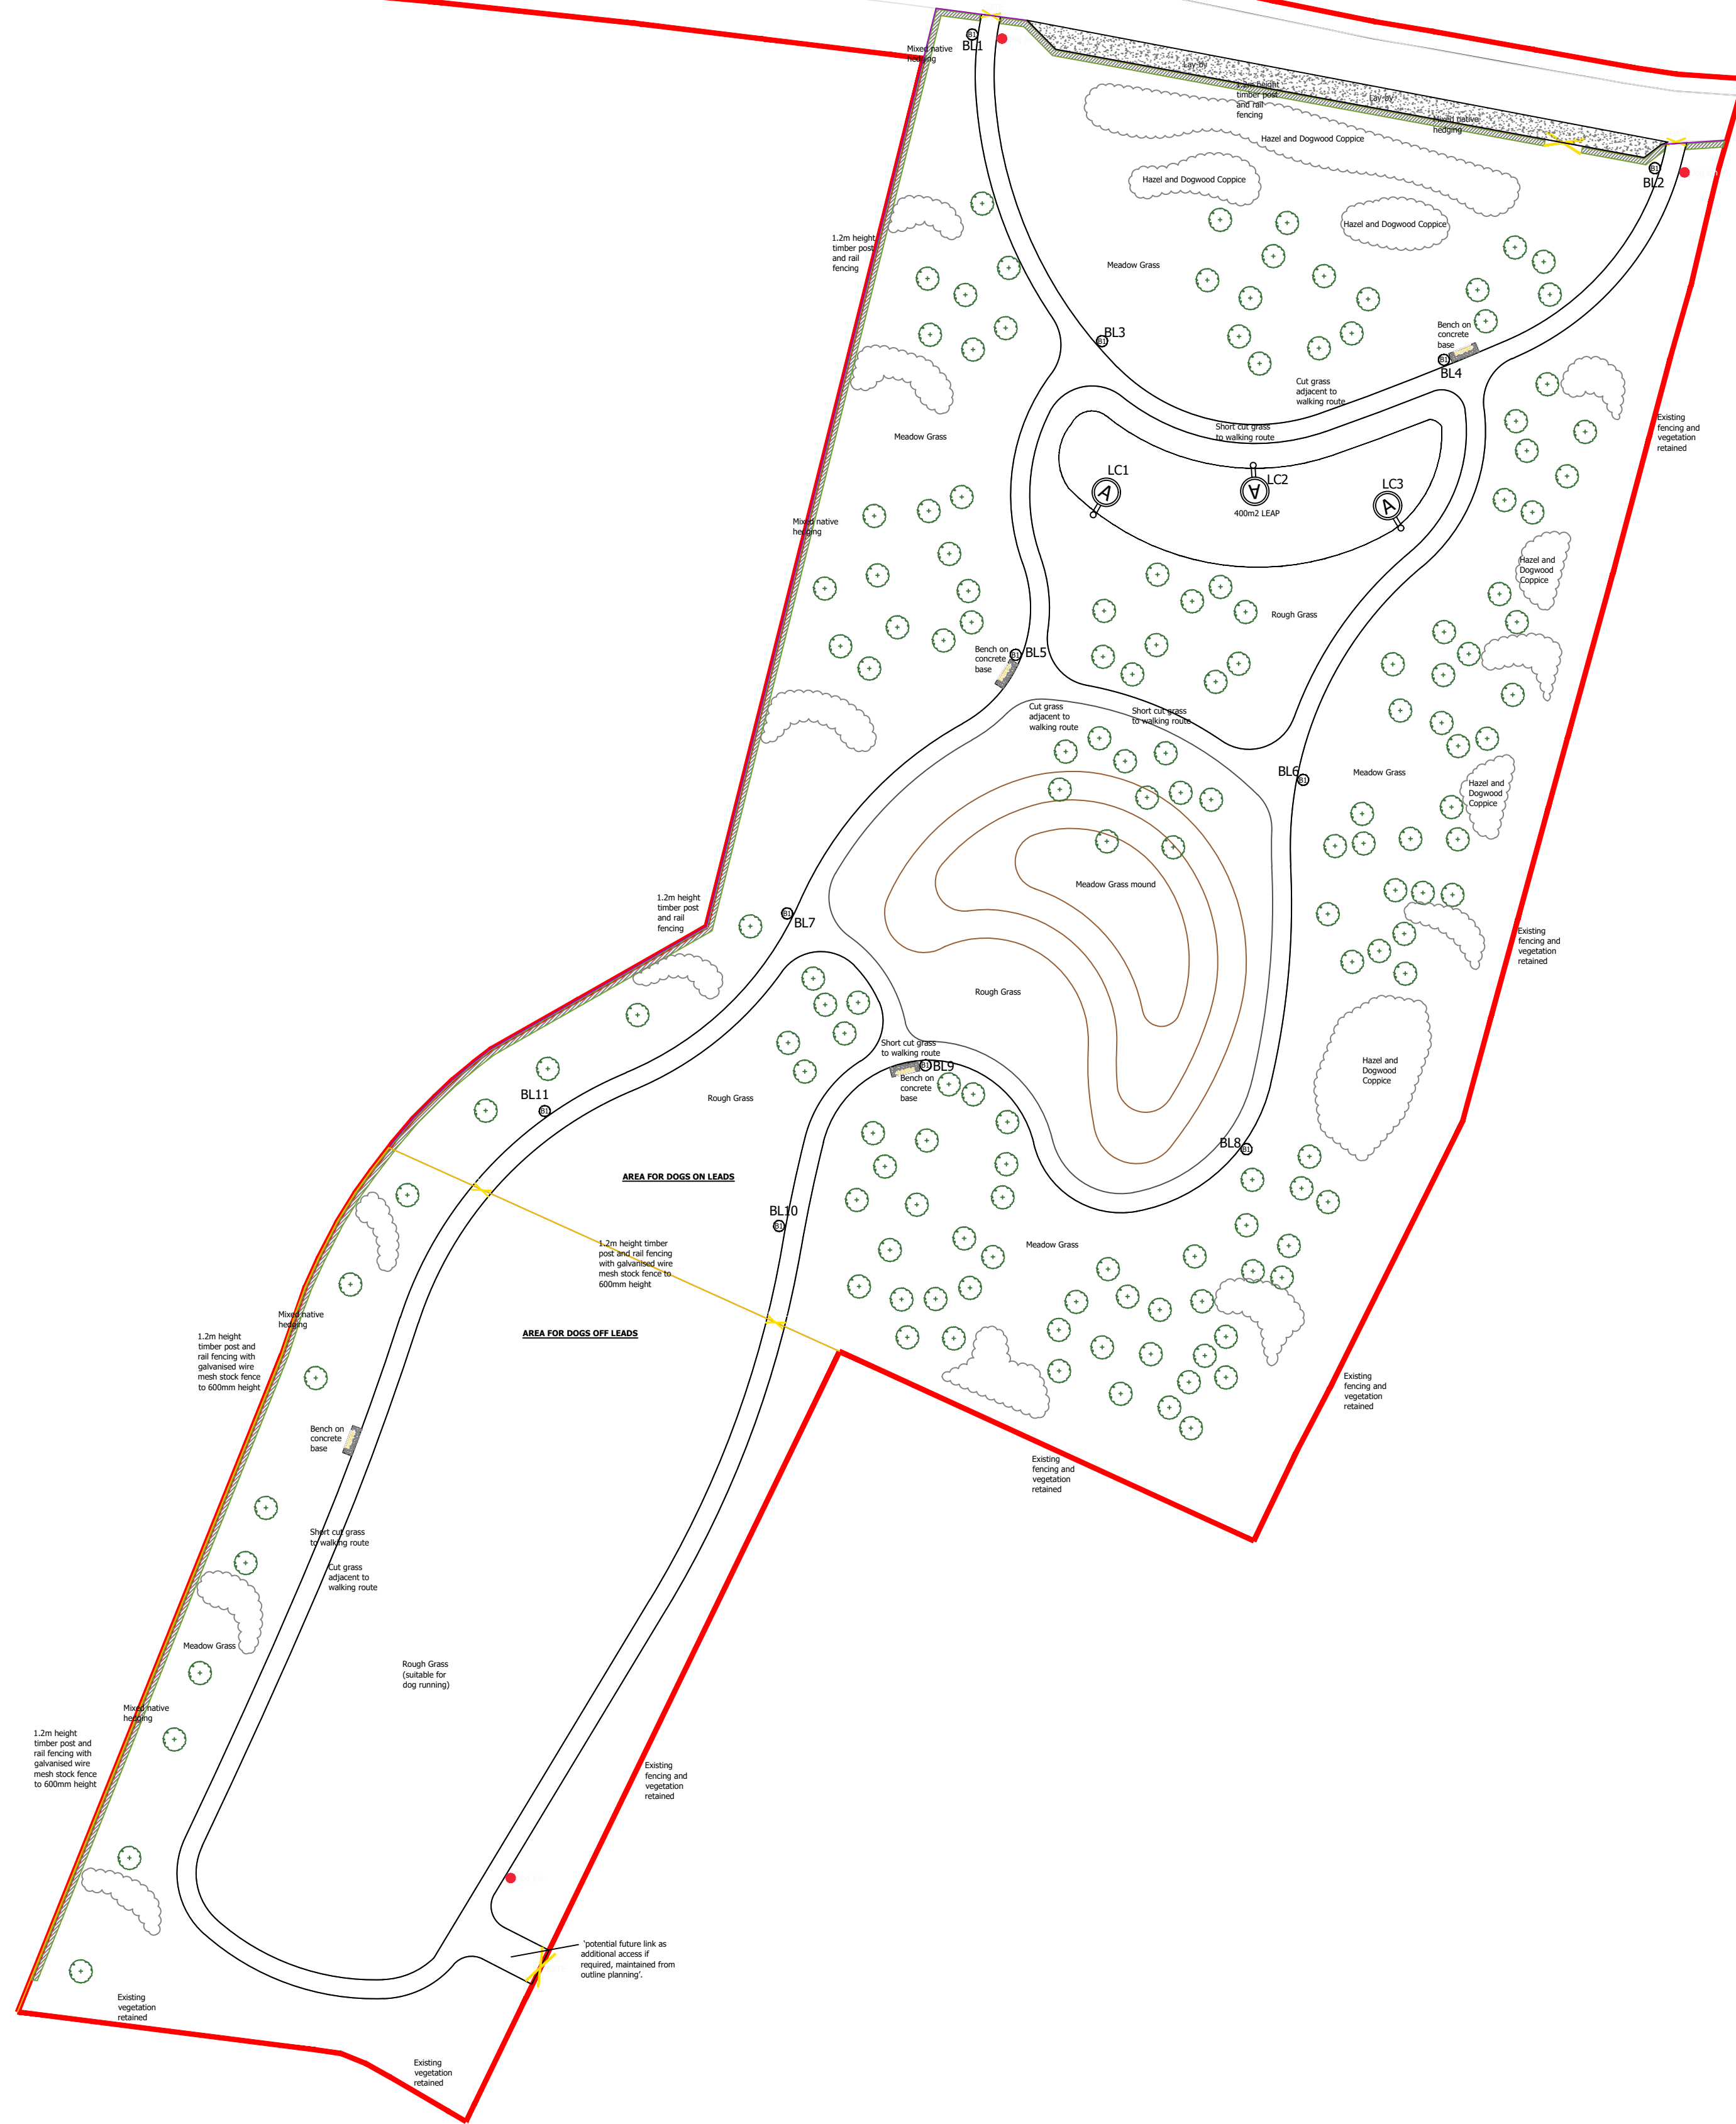


RESIDUAL DESIGN HAZARDS

1. STRIKING OF UNDERGROUND UTILITY SERVICES DURING INSTALLATION, MAINTENANCE AND DEMOLITION.

- RESIDUAL DESIGN HAZARDS**

 1. STRIKING OF UNDERGROUND UTILITY SERVICES DURING INSTALLATION, MAINTENANCE AND DEMOLITION.

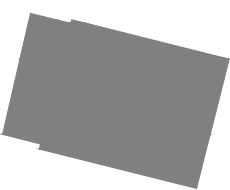

 RESIDUAL DESIGN HAZARDS

DRAWING TO BE READ IN CONJUNCTION WITH THE DESIGNER
RISK ASSESSMENT DOCUMENT NUMBER: 100090.S278.001

CONTRACTORS MUST SEEK MOST UP-TO-DATE UTILITY
DRAWINGS BEFORE ANY WORK COMMENCES

 **RESIDUAL DESIGN HAZARDS**

DRAWING TO BE READ IN CONJUNCTION WITH THE DESIGNER
RISK ASSESSMENT DOCUMENT NUMBER: 100090.S278.001

CONTRACTORS MUST SEEK MOST UP-TO-DATE UTILITY
DRAWINGS BEFORE ANY WORK COMMENCES

 **RESIDUAL DESIGN HAZARDS**

DRAWING TO BE READ IN CONJUNCTION WITH THE DESIGNER
RISK ASSESSMENT DOCUMENT NUMBER: 100090.S278.001

CONTRACTORS MUST SEEK MOST UP-TO-DATE UTILITY
DRAWINGS BEFORE ANY WORK COMMENCES

NOTES

1. ALL COLUMNS TO BE DISTRIBUTION NETWORK OPERATOR (DNO) SUPPLIED UNLESS OTHERWISE DETAILED
2. ALL EQUIPMENT TO BE MADE ELECTRICALLY SAFE PRIOR TO COMMENCEMENT OF WORKS.
3. ALL ELECTRICAL WORKS TO BE CARRIED OUT IN ACCORDANCE WITH BS 7671:2018 IET WIRING REGULATIONS 18TH EDITION.
4. CONTRACTOR TO LIAISE WITH DISTRIBUTION NETWORK OPERATOR PRIOR TO COMMENCEMENT OF WORKS.
5. COLUMNS TO BE DESIGNED TO BS EN 40.

- NOTES**

 1. ALL COLUMNS TO BE DISTRIBUTION NETWORK OPERATOR (DNO) SUPPLIED UNLESS OTHERWISE DETAILED
 2. ALL EQUIPMENT TO BE MADE ELECTRICALLY SAFE PRIOR TO COMMENCEMENT OF WORKS.
 3. ALL ELECTRICAL WORKS TO BE CARRIED OUT IN ACCORDANCE WITH BS 7671:2018 IET WIRING REGULATIONS 18TH EDITION.
 4. CONTRACTOR TO LIAISE WITH DISTRIBUTION NETWORK OPERATOR PRIOR TO COMMENCEMENT OF WORKS.
 5. COLUMNS TO BE DESIGNED TO BS EN 40.


KEY

 COLUMN: NEW 5m MID-HINGED TUBULAR STEEL

LUMINAIRE: POST TOP URBIS AXIA 2.1 5241 16LED
600mA VWW 3.36klm

TILT: 0°

 URBIS PHAROS BOLLARD 5119 ASYMMETRICAL 8
LEDS 350MA NW CYLINDRICAL, PC, SMOOTH 356012

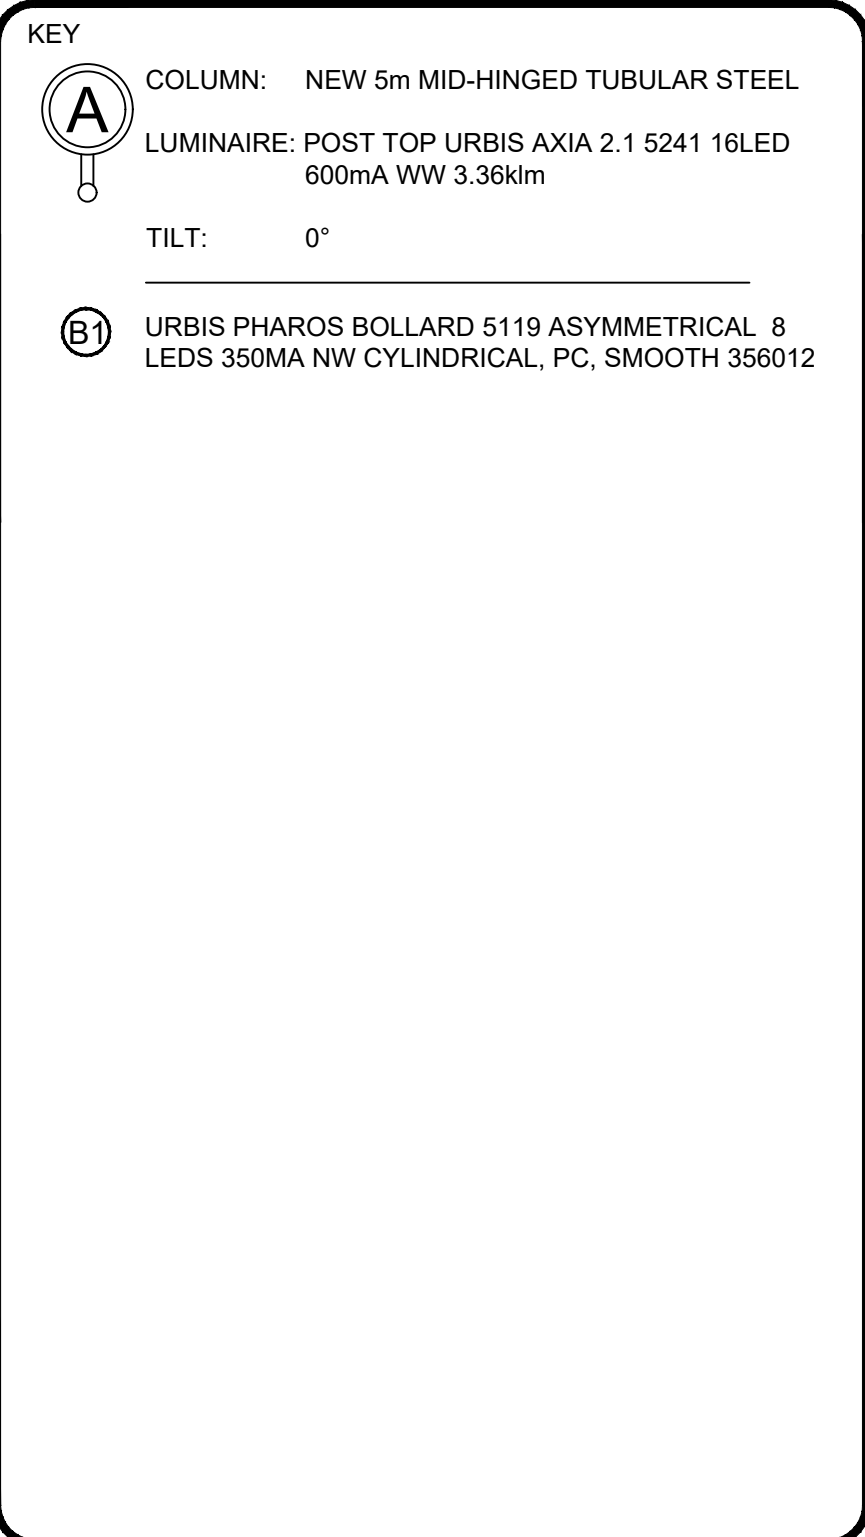

KEY

 COLUMN: NEW 5m MID-HINGED TUBULAR STEEL

 LUMINAIRE: POST TOP URBIS AXIA 2.1 5241 16LED
600mA VWW 3.36klm

TILT: 0°

 URBIS PHAROS BOLLARD 5119 ASYMMETRICAL 8
LEDS 350MA NW CYLINDRICAL, PC, SMOOTH 356012


KEY

 COLUMN: NEW 5m MID-HINGED TUBULAR STEEL

 LUMINAIRE: POST TOP URBIS AXIA 2.1 5241 16LED
600mA VWW 3.36klm

TILT: 0°

 URBIS PHAROS BOLLARD 5119 ASYMMETRICAL 8
LEDS 350MA NW CYLINDRICAL, PC, SMOOTH 356012

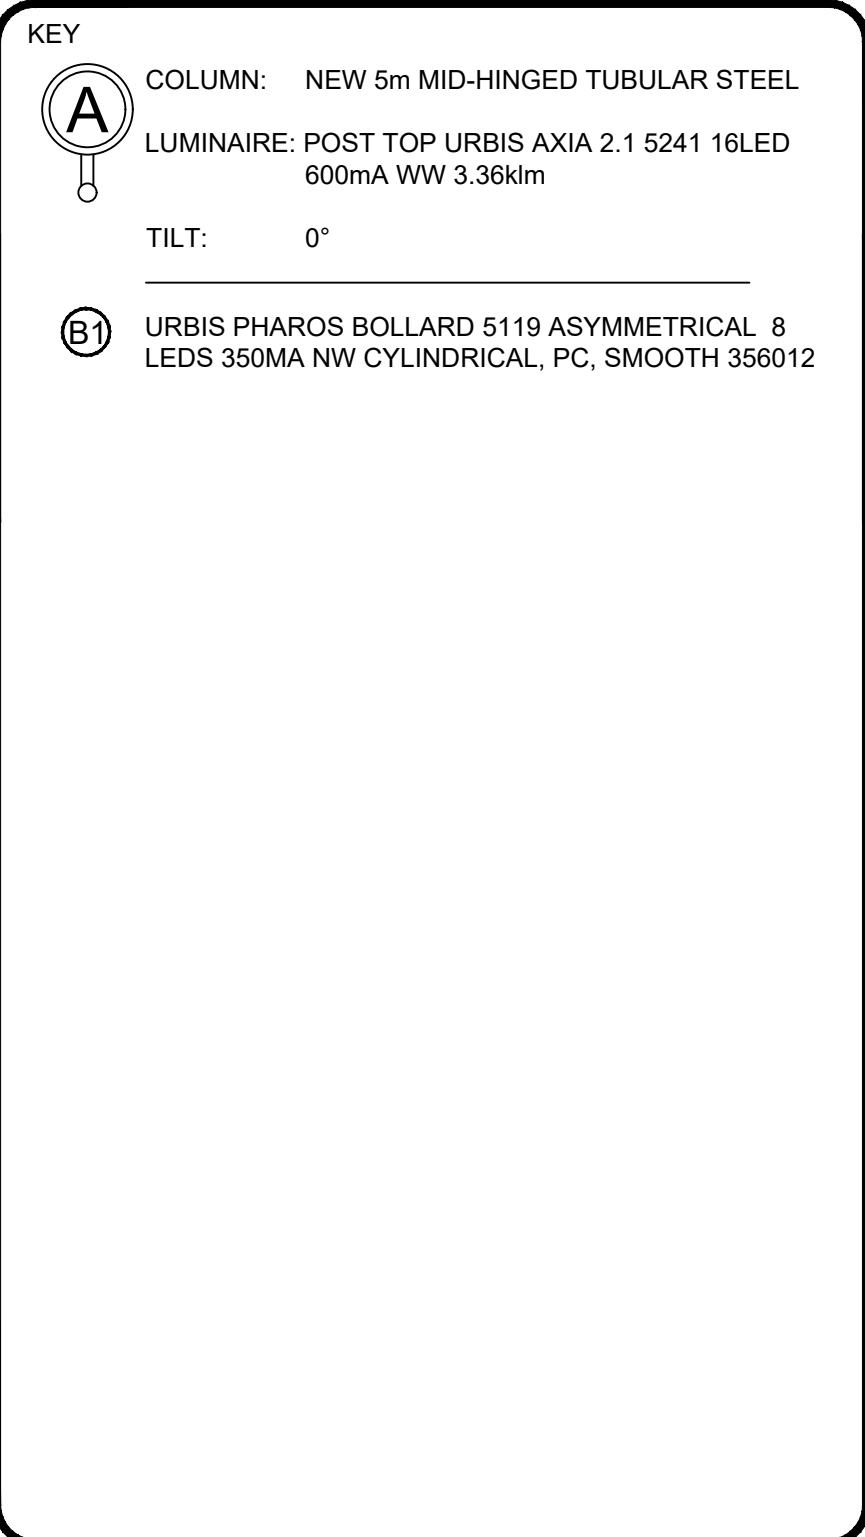

KEY

 COLUMN: NEW 5m MID-HINGED TUBULAR STEEL

 LUMINAIRE: POST TOP URBIS AXIA 2.1 5241 16LED
600mA VWW 3.36klm

TILT: 0°

 URBIS PHAROS BOLLARD 5119 ASYMMETRICAL 8
LEDS 350MA NW CYLINDRICAL, PC, SMOOTH 356012

P01 FIRST ISSUE 06/11/2019

P01 FIRST ISSUE 06/11/2019

Status	FOR APPROVAL
--------	--------------

Status	FOR APPROVAL
--------	--------------



**j lighting
design**
www.josephlighting.co.uk

Client

PRIVATE DEVELOPER

Client

PRIVATE DEVELOPER

Project Name
SUMMER LANE, PAGHAM
PUBLIC OPEN SPACE

Project Name
SUMMER LANE, PAGHAM
PUBLIC OPEN SPACE

Drawing Title

PROPOSED LIGHTING LAYOUT

Drawing Title

PROPOSED LIGHTING LAYOUT

Original Drawing Size : A1	Drawn: JJ	Created:
Scale : 1:500	Checked: JJJ	06/11/19
Drawing No 100090.POS.1301		Rev P01