


1. STRIKING OF UNDERGROUND UTILITY SERVICES [REDACTED] INSTALLATION, MAINTENANCE AND DEMOLITION.

NG T

DRAWING TO BE READ IN CONJUNCTION WITH THE DESIGN
RISK ASSESSMENT DOCUMENT NUMBER: 100090.S278.001

 
CONTRACTORS MUST SEEK MOST UP-TO-DATE UTILITY
DRAWINGS BEFORE ANY WORK COMMENCES

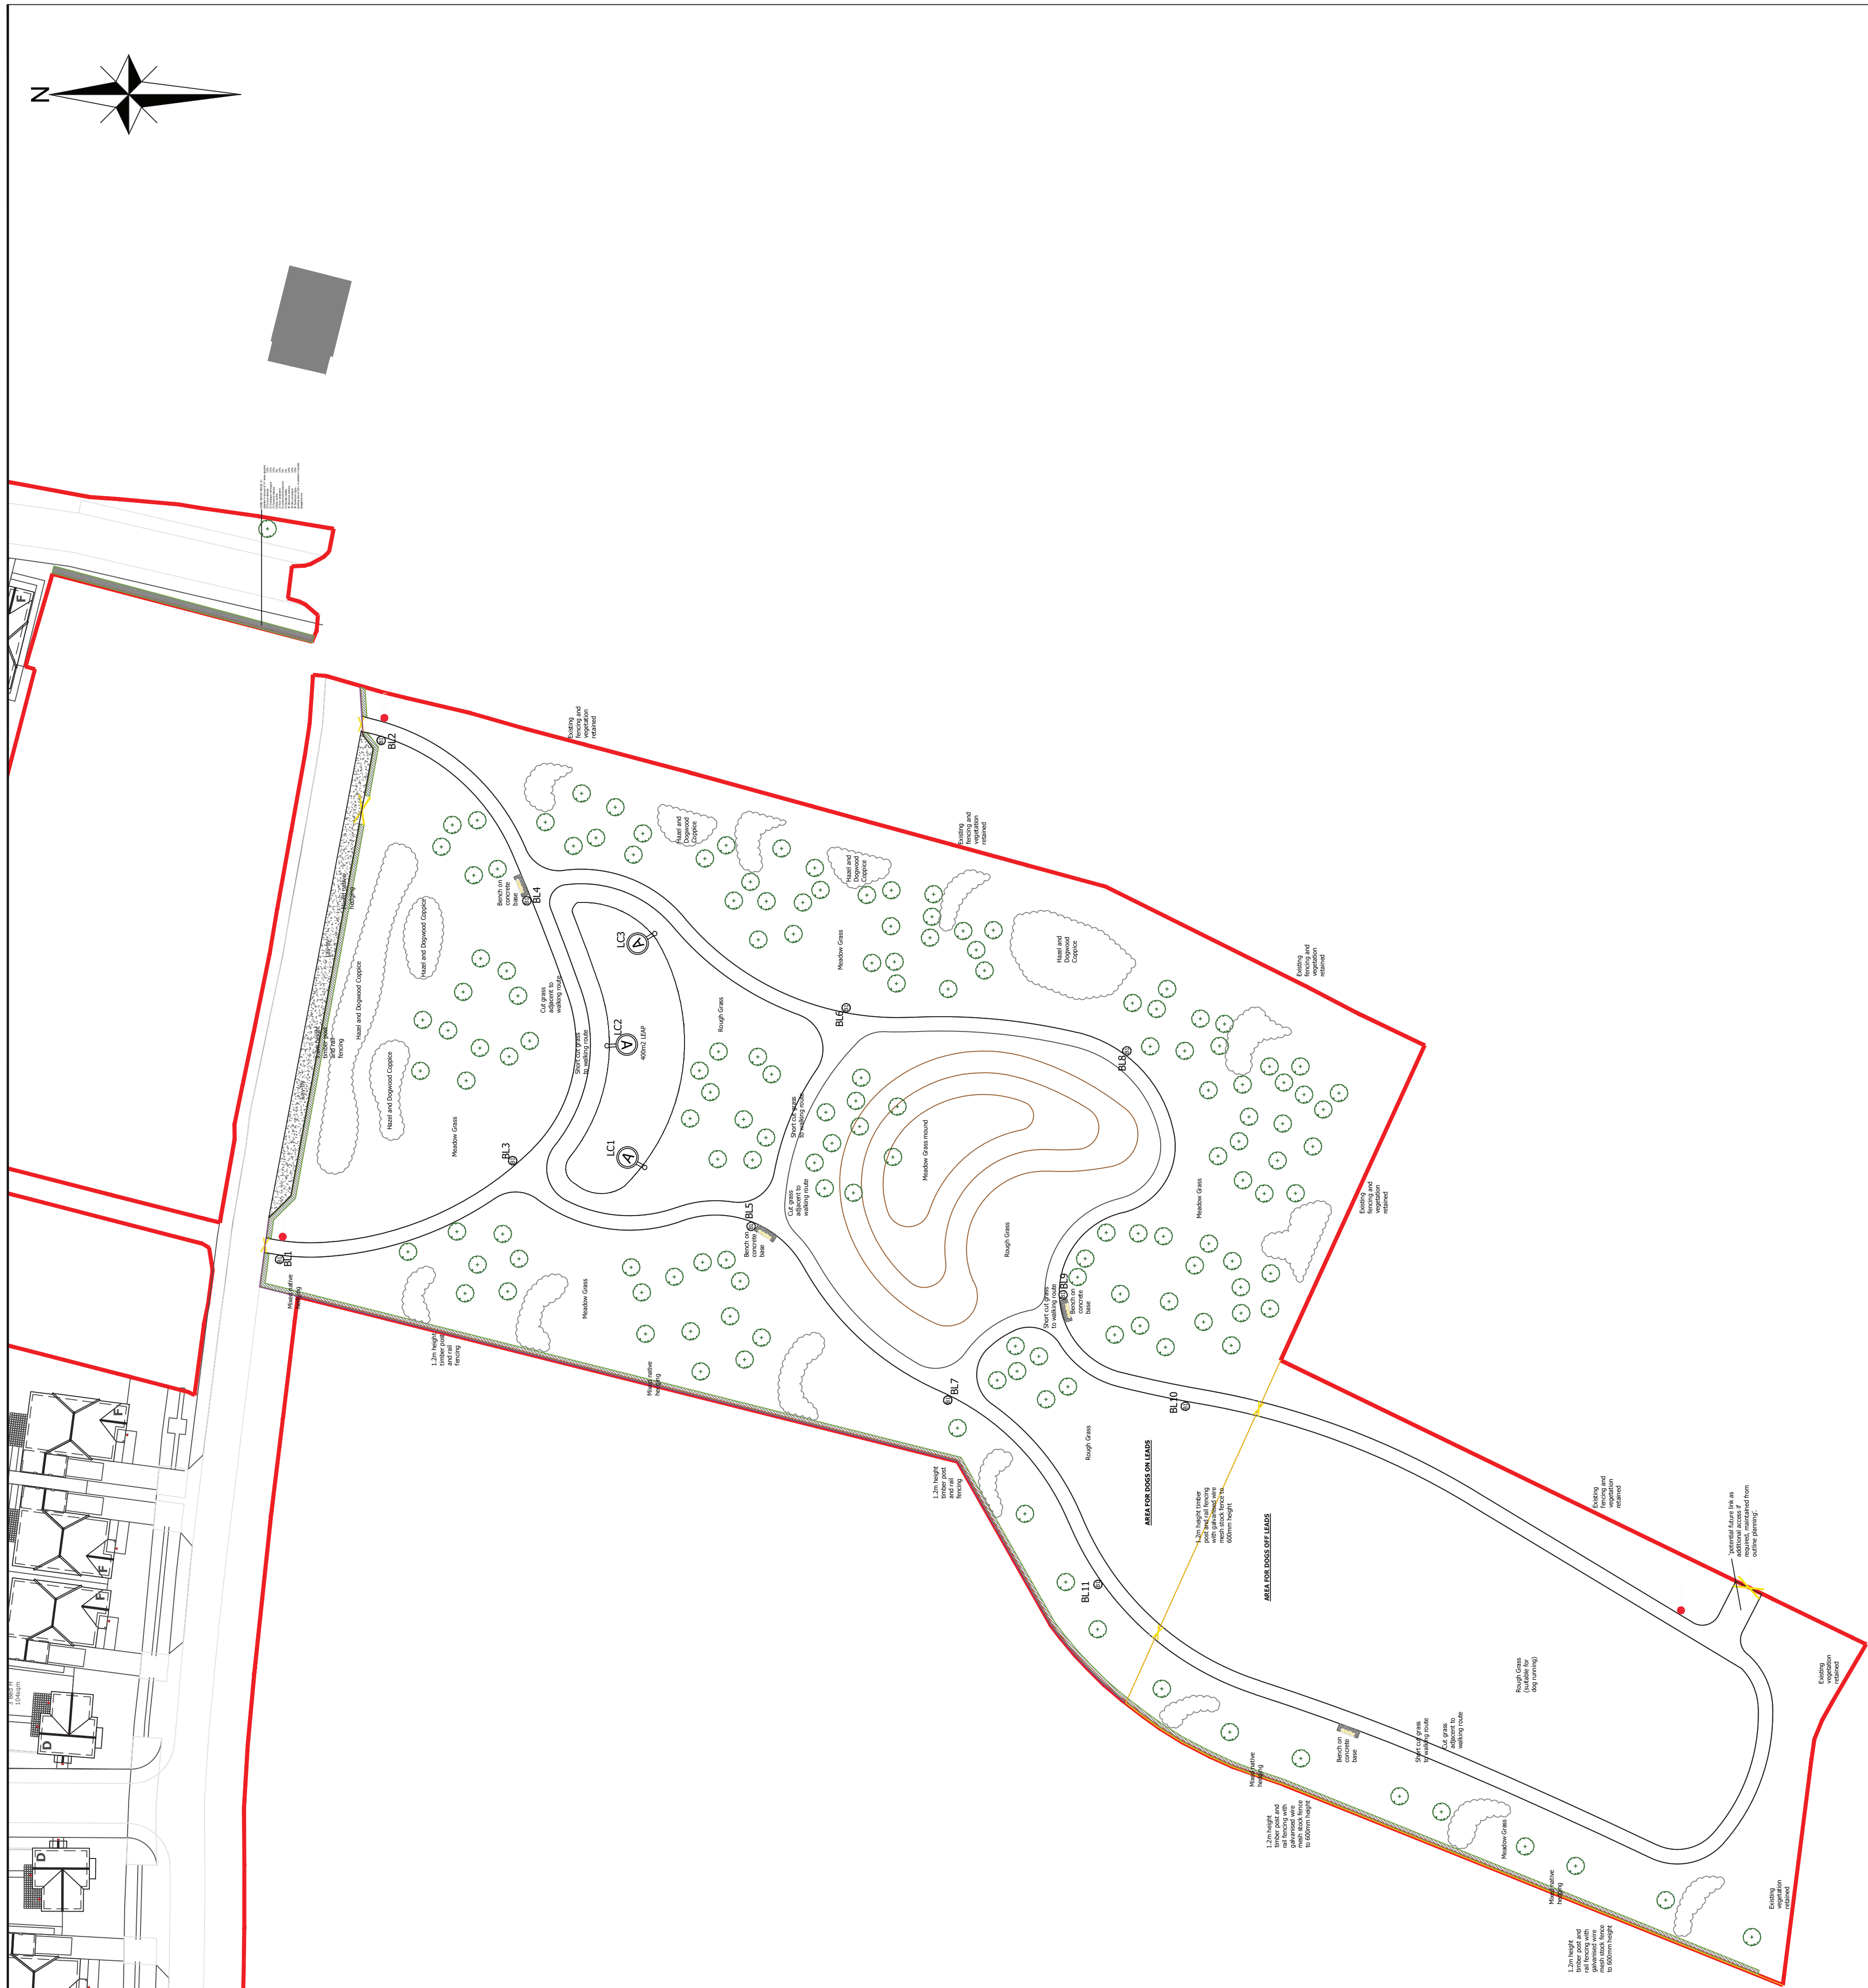

NOTES

1. ALL COLUMNS TO BE DISTRIBUTION NETWORK OPERATOR (DNO) SUPPLIED UNLESS OTHERWISE DETAILED
2. ALL EQUIPMENT TO BE MADE ELECTRICALLY SAFE PRIOR TO COMMENCEMENT OF WORKS.
3. ALL ELECTRICAL WORKS TO BE CARRIED OUT IN ACCORDANCE WITH BS 7671:2018 IET WIRING REGULATIONS 18TH EDITION.
4. CONTRACTOR TO LIAISE WITH DISTRIBUTION NETWORK OPERATOR PRIOR TO COMMENCEMENT OF WORKS.
5. COLUMNS TO BE DESIGNED TO BS EN 40.

KEY



COLUMN: NEW 5m MID-HINGED TUBULAR STEEL
LUMINAIRE: POST TOP URBIS AXIA 2.1 5241 16LED
600mA WW 3.38klm

TILT: 0°



URBIS PHAROS BOLLARD 5119 ASYMMETRICAL 8
LEDS 350MA NW CYLINDRICAL, PC, SMOOTH 356012

P01 FIRST ISSUE

06/11/2019

Status

FOR APPROVAL

lighting
design

www.josephlighting.co.uk

Client

PRIVATE DEVELOPER

Project Name

SUMMER LANE, PAGHAM
PUBLIC OPEN SPACE

Drawing Title

PROPOSED LIGHTING LAYOUT

Original Drawing Size :	A1	Drawn: JJ	Created:
-------------------------	----	-----------	----------

0	-	0
1	=	0
2	+	0
3	+	0
4	+	0
144	+	0

Scale : 1:500	Checked: JLC	06/11/19
---------------	--------------	----------

Drawing No	Rev
1	1