



PRINT @ A2 FOR 1:50 SCALE

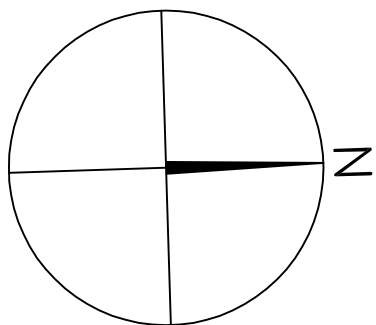

DECORATE ALL AREAS.
INSTALL L2 FIRE ALARM SYSTEM WITH
SMOKE DETECTION AND EMERGENCY
LIGHTING TO ALL AREAS.

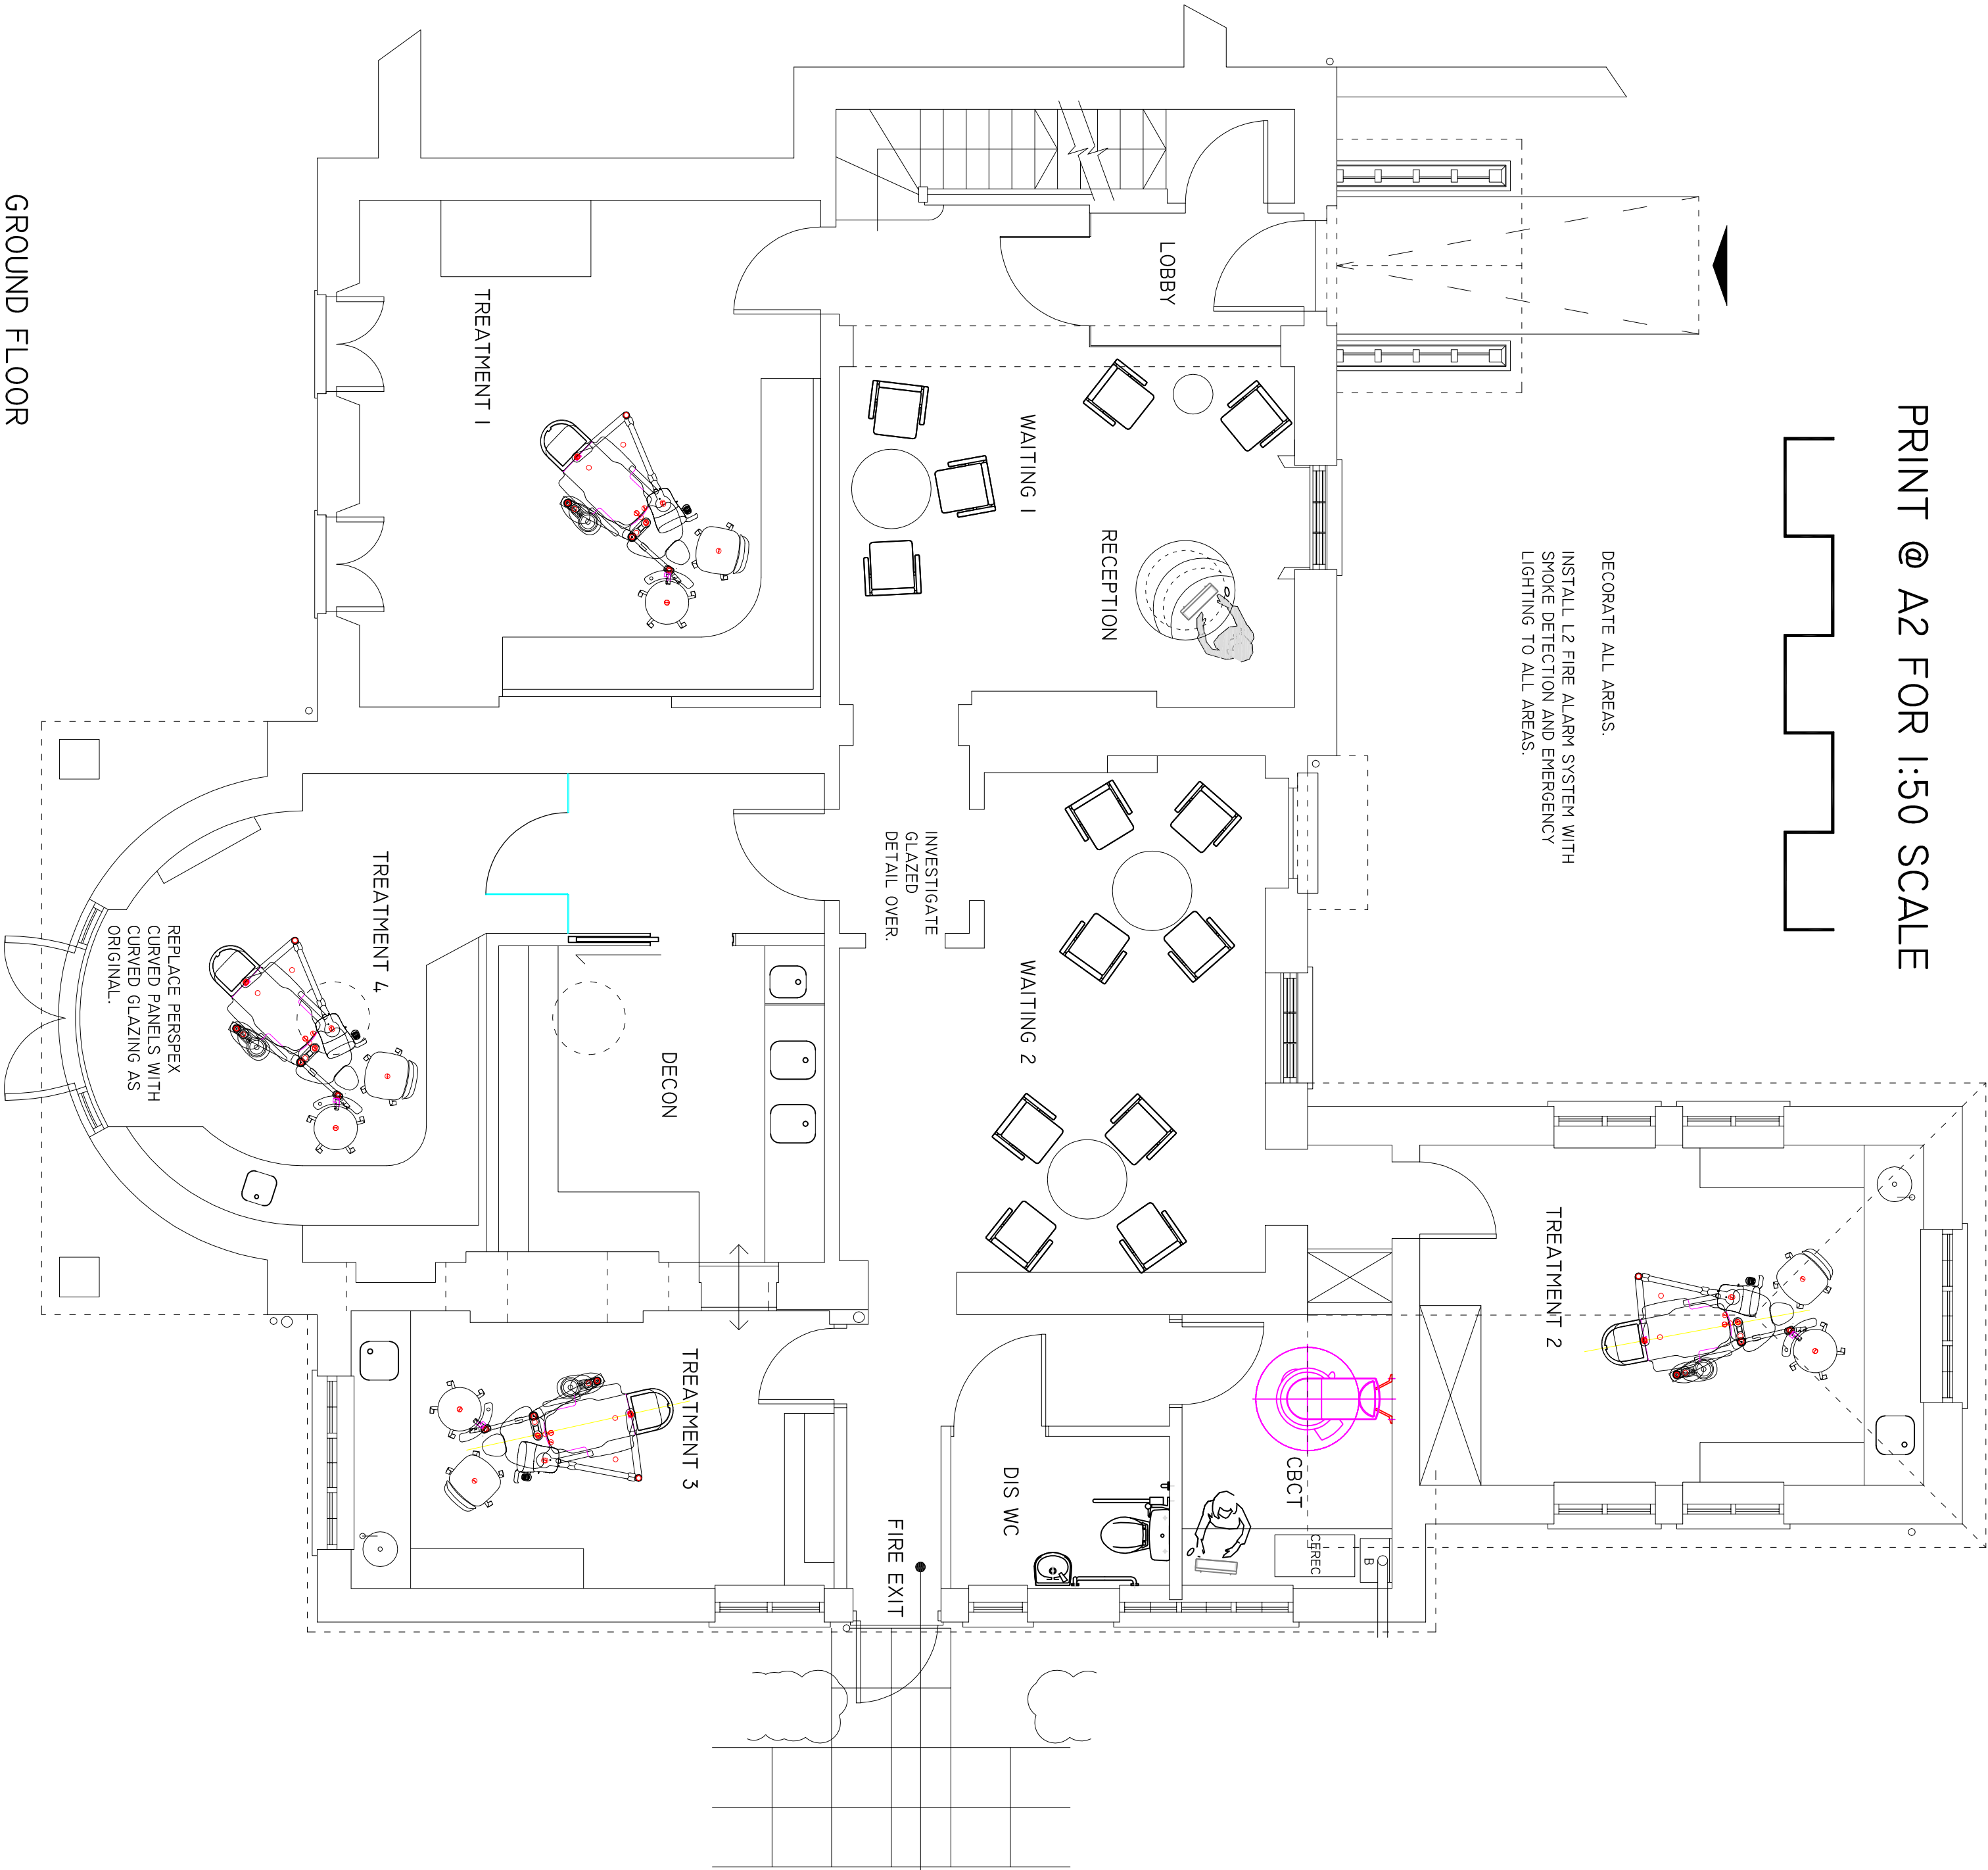

GROUND FLOOR

GREY ASSOCIATES

67 RODNEY ROAD WALTON ON THAMES KT12 3LG
T: 07957 810940 E: INFO@GREYASSOCIATES.CO.UK

CLIENT ABBOTS LODGE DENTAL PRACTICE

TITLE 85 THE STREET, RUSTINGTON, BN16 3NL

DRAWING PROPOSED FIRE EXIT

DATE 15.06.19 SCALE 1:50

DRAWING No. ALDP_PS_030.19

REVISION