


This drawing may not be reproduced, made use of or issued to a third party without permission of : Gleeds Building Surveying Ltd. DO NOT SCALE - The contractor is responsible for checking all details and dimensions on site and using these in his tender submission and all subsequent work on site. THIS IS A CAD DRAWING - DO NOT ALTER

Rev.	Description	By	Date
------	-------------	----	------

LUMINAIRE SCHEDULE				
Symbol	Label	Qty	Catalog Number	Description
	A1	1	1 x DSX1.2.LA064.AY on 6m Column	D-Series 1 Luminaire
	A1st	1	1 x DSX1.2.LA064.AY. BLS on 6m Column and Backlight Shield. 5 Degree Tilt Bracket	D-Series 1 Luminaire with Back light shield
	B1t	3	1 x DSX1.2.LA064.FW on 6m Column 5 Degree Tilt Bracket	D-Series 1 Luminaire
	B1st	1	1 x DSX1.2.LA064.FW. BLS on 6m Column and Backlight Shield. 5 Degree Tilt Bracket	D-Series 1 Luminaire with Back light shield
	C	18	AME.RO at 3m AFFL	External high output emergency bulkhead

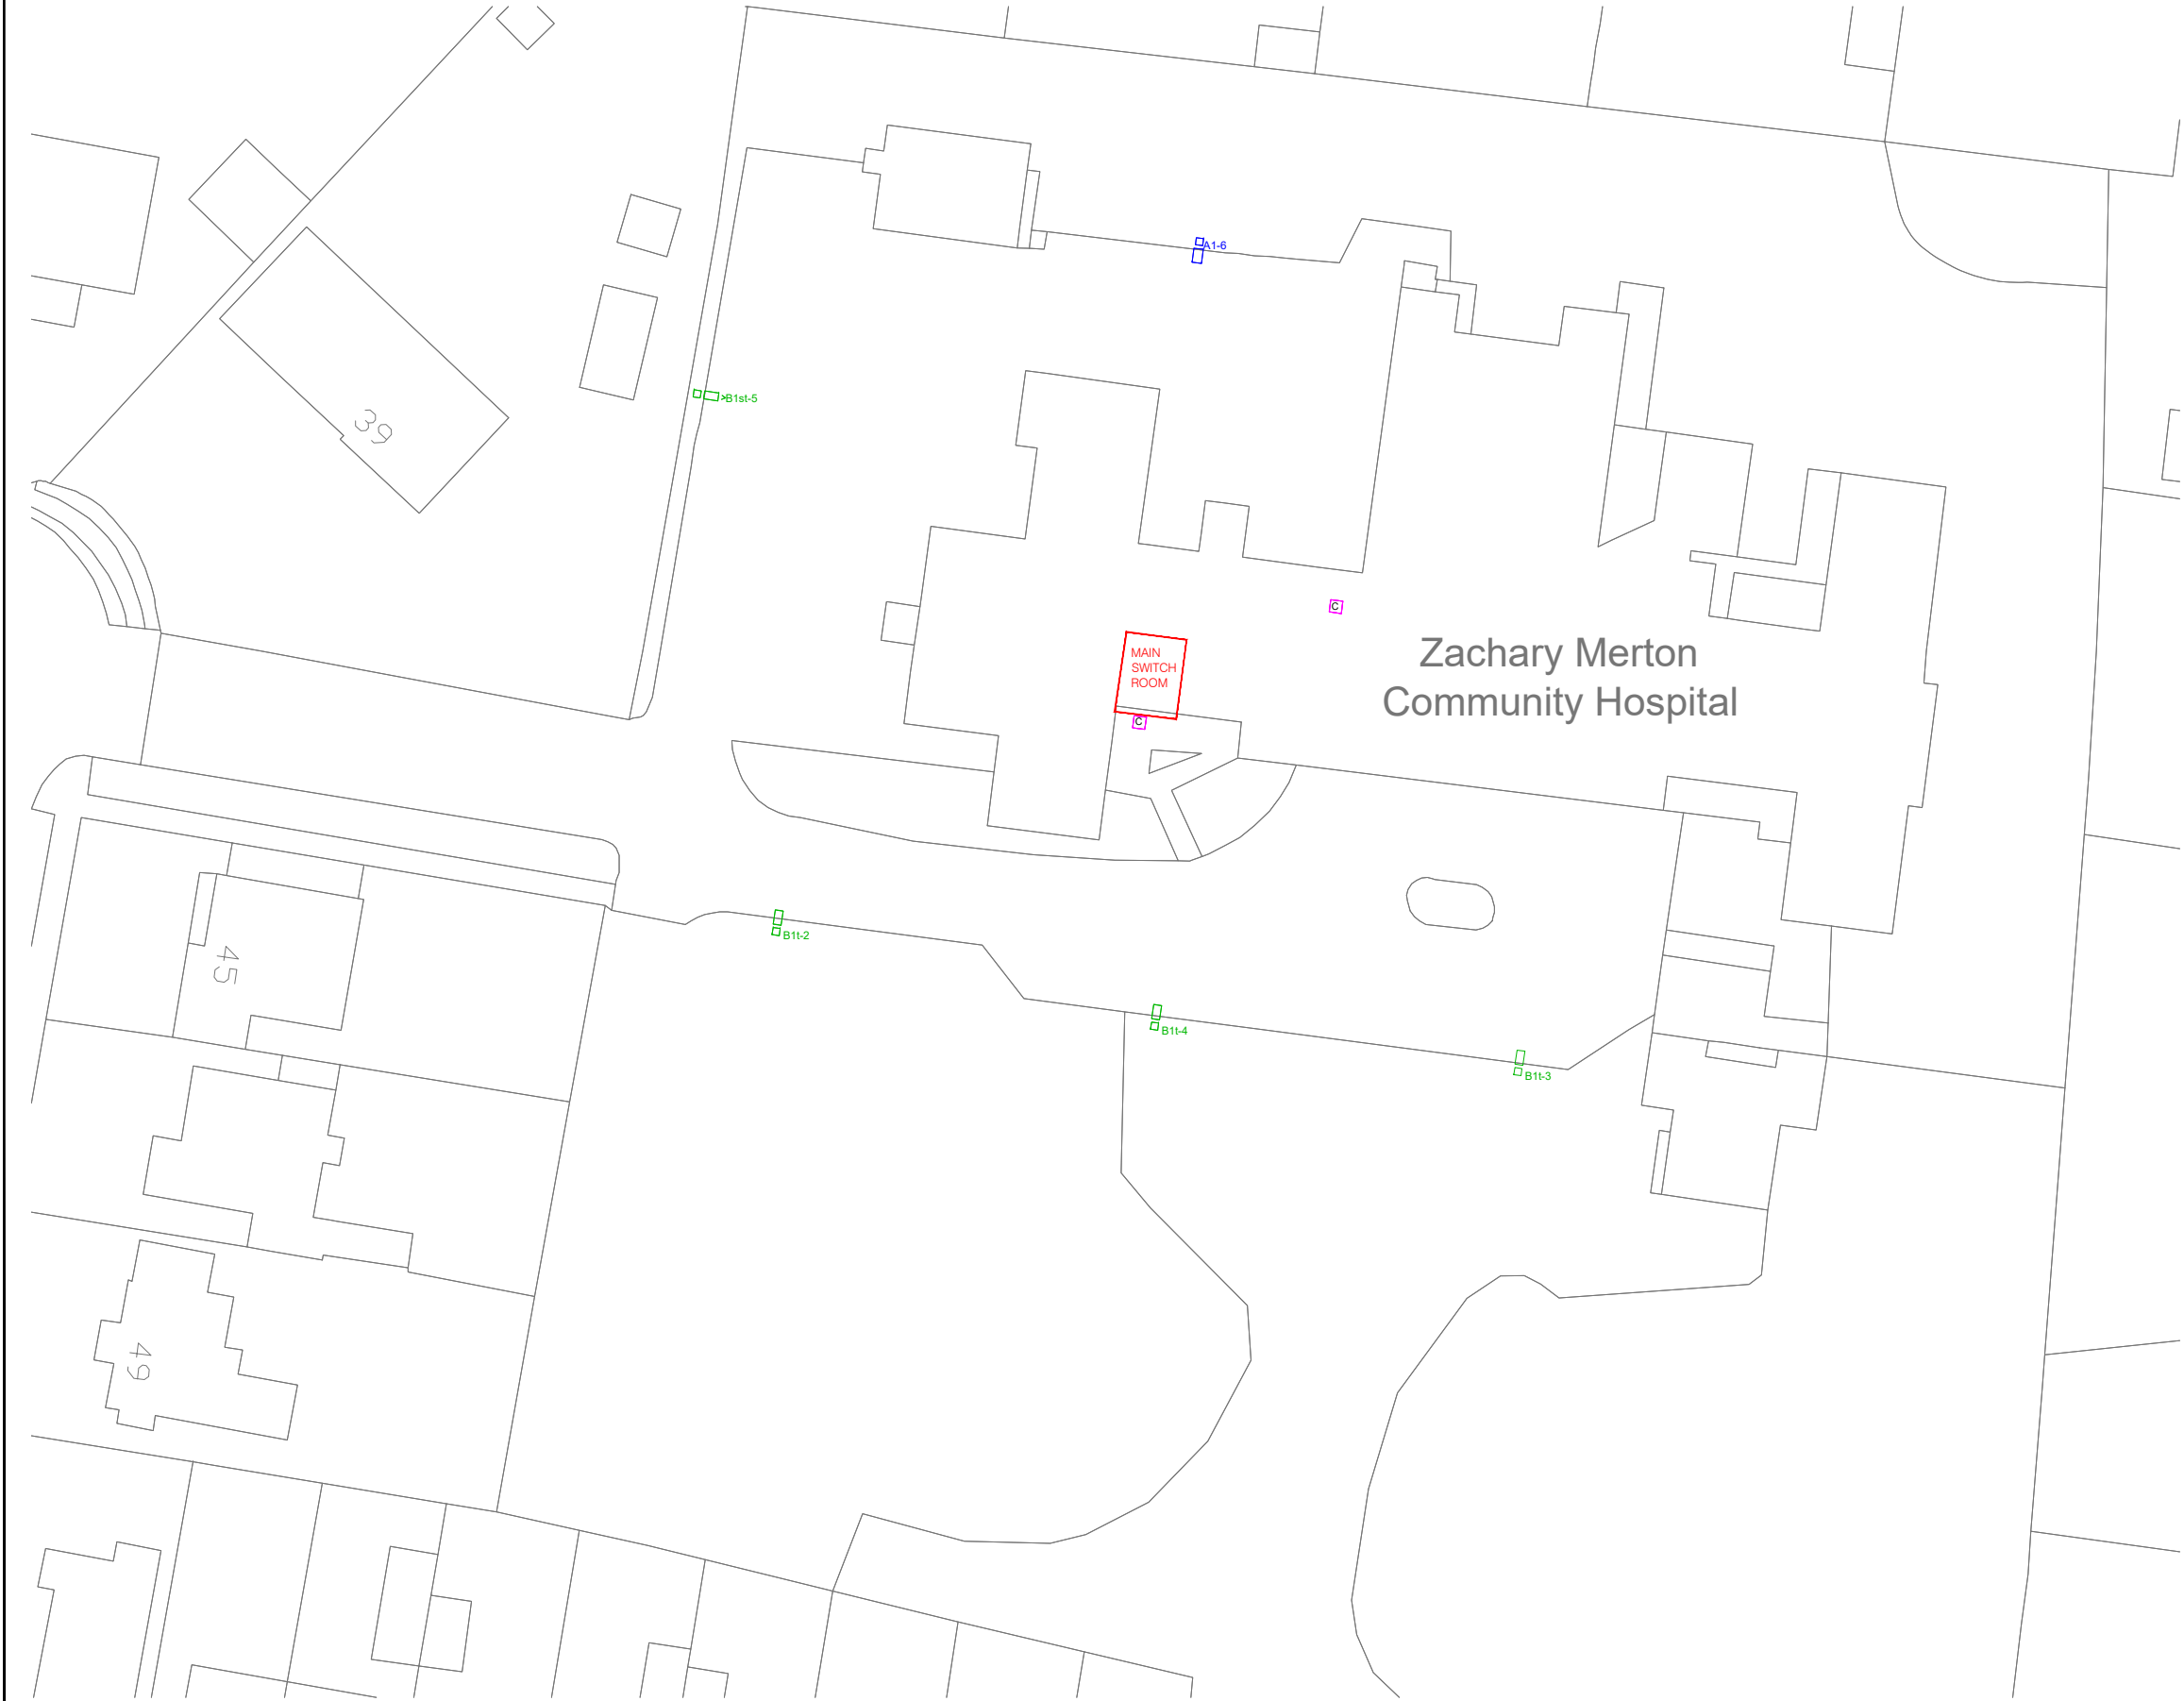

Client  Property Services	Project Zachary Merton Hospital Glenville Road, Rustington, Littlehampton. BN16 2EA	Drawing Title Proposed Site Plan		Drawing Status	Drawing No. NTBS3223 / ZMH / 05						
				Scale 1:500 Original Sheet Size A3							
<table><tr><td>Drawn pmb</td><td>Checked DJ</td></tr><tr><td>Date 10 / 2019</td><td>Rev.</td></tr></table>				Drawn pmb	Checked DJ	Date 10 / 2019	Rev.	<table><tr><td>Gleeds Building Surveying T: +44 (0)115 977 8000</td><td>gleeds.com   </td></tr></table>		Gleeds Building Surveying T: +44 (0)115 977 8000	gleeds.com   
Drawn pmb	Checked DJ										
Date 10 / 2019	Rev.										
Gleeds Building Surveying T: +44 (0)115 977 8000	gleeds.com   										