


SURFACE WATER DRAINAGE


DISCHARGE INTO EXISTING SYSTEM.

100mm GUTTERS TO DISCHARGE INTO 70mm DOWNPIPES
-MODIFIED TO SUIT REVISED ROOF LAYOUT.

PROVIDE MECHANICAL EXTRACT
MIN. 60l/s TO KITCHEN, 30l/s TO
UTILITY & 15l/s TO SHOWER ROOM
& WC

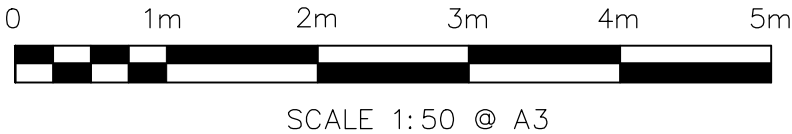

BRICK RETURNS
TO BE MIN. 665mm

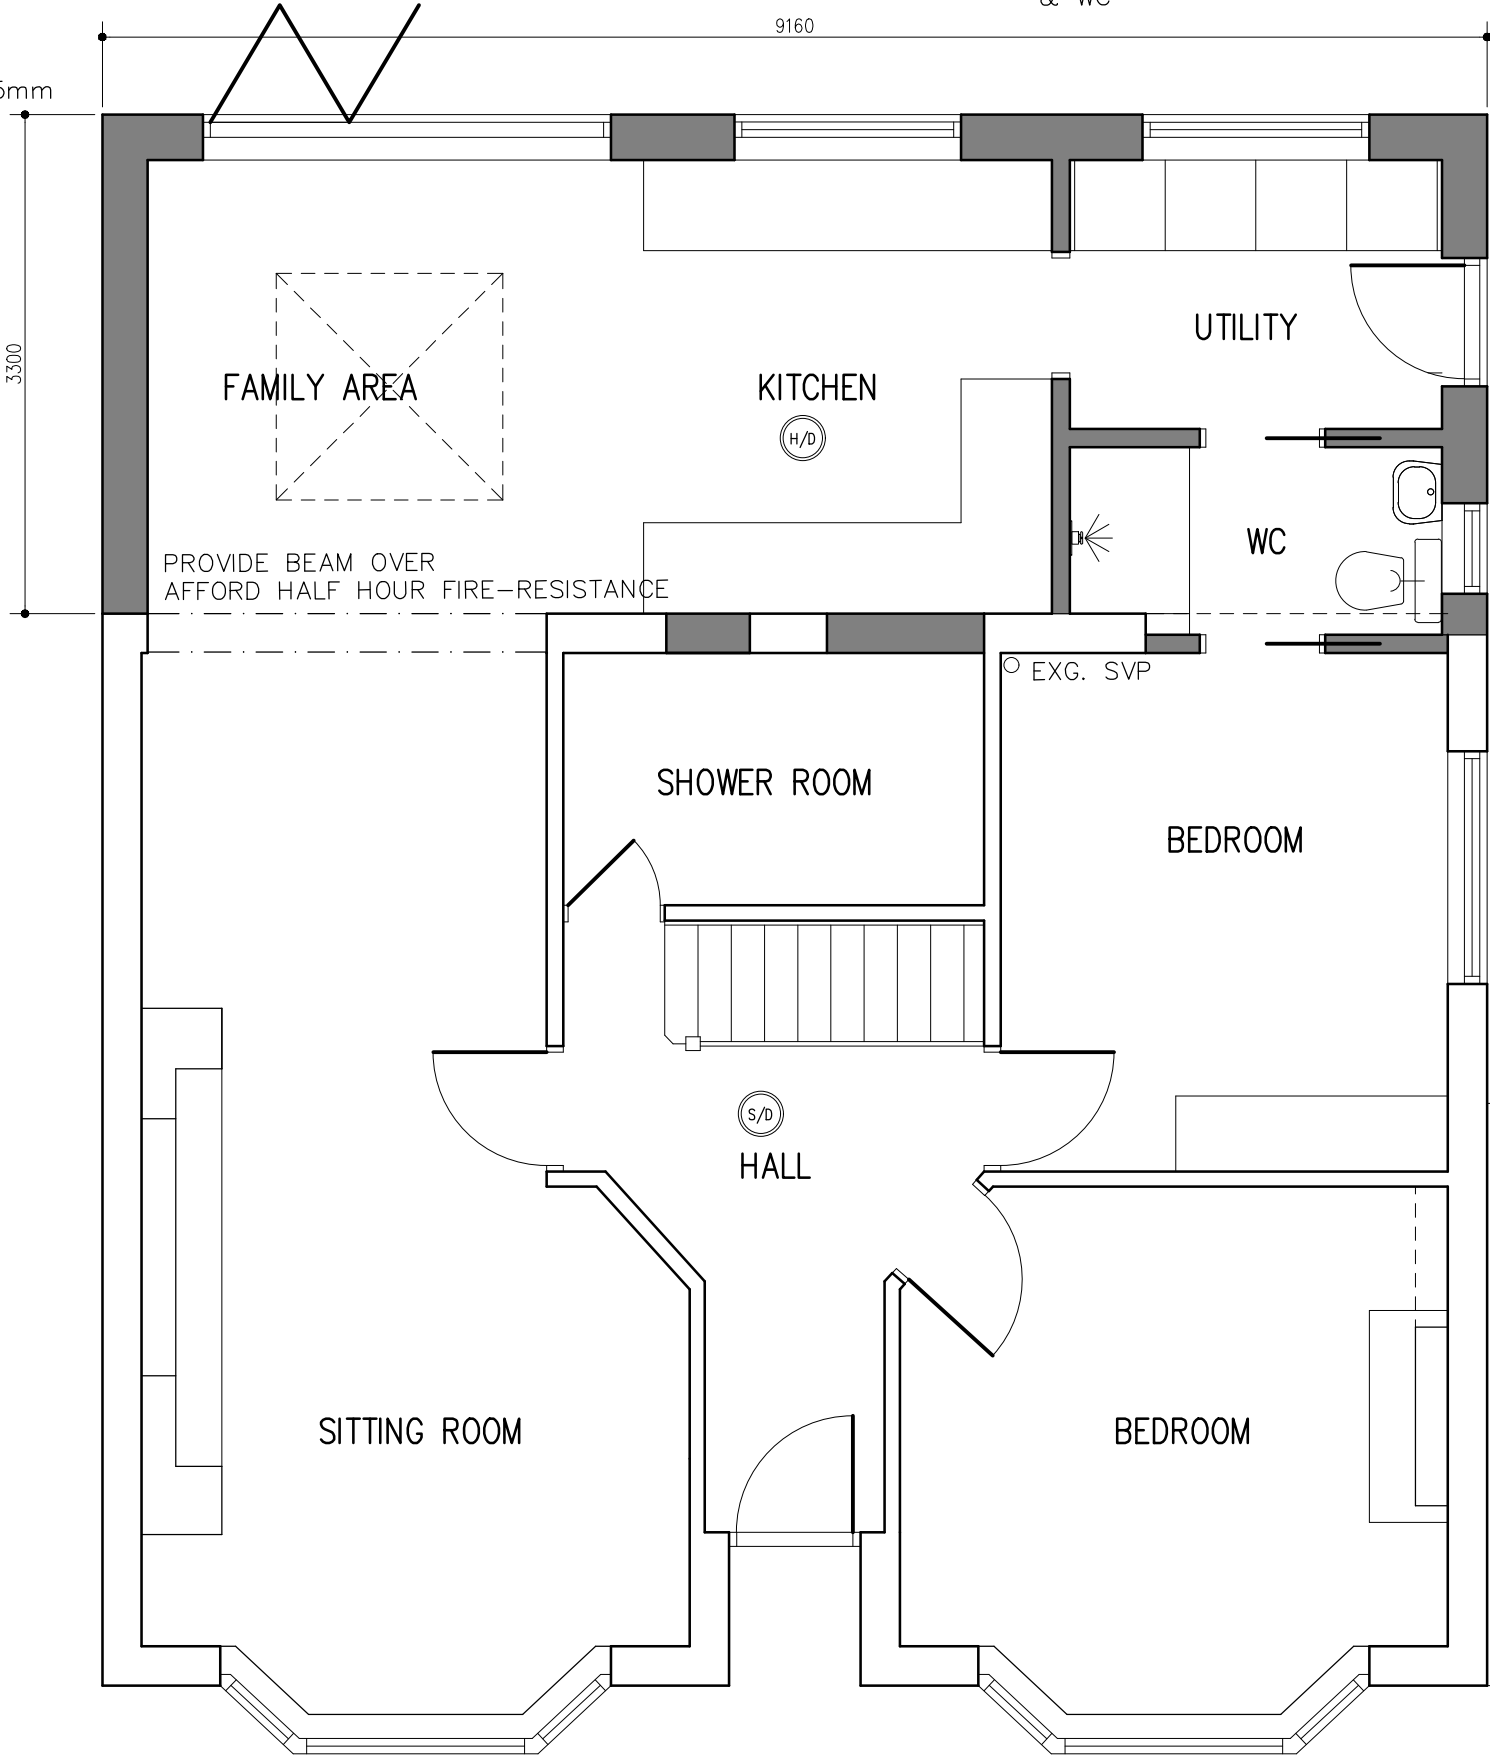

SMOKE DETECTORS

- (S/D) SMOKE DETECTOR (MAINS OPERATED)
- (H/D) HEAT DETECTOR (MAINS OPERATED)

INTERCONNECTED SMOKE ALARMS AS INDICATED TO BE PERMANENTLY
WIRED TO A SEPARATE FUSED CIRCUIT.
TO BE POSITIONED AS SHOWN ON PLANS BUT LOCATED A MINIMUM OF
300mm FROM ANY LIGHT FITTING & WITHIN 7500mm FROM ALL
HABITABLE ROOMS.

NOTE: CAVITIES TO BE MAINTAINED
AT ABUTMENT OF NEW & EXISTING
WALLS

NOTE: FOUL DRAINAGE LAYOUT SUBJECT TO
EXPOSURE ONCE WORK COMMENCES ON SITE.
SYSTEM TO BE MODIFIED/ADAPTED TO SUIT
EXISTING & NEW FOUL DRAINAGE REQUIREMENTS.
ALL IN ACCORDANCE WITH PART H OF CURRENT
BUILDING REGS & TO BUILDING CONTROL OFFICERS
AGREEMENT ON SITE.

PARKING

REMOVE EXISTING
GARAGE

FOR MR & MRS YOUNG		
SITE 'ROSSIDA', STONEFIELDS, RUSTINGTON. BN16 3BY		
TITLE EXTENSION & ALTERATIONS PROPOSED FLOOR PLAN		
SCALE 1:50 @ A3	DRAWN AH 08/21	DRAWING NO. 07 REV A

REV. A—SCALE NOTE AMENDED IN TITLE BLOCK
16/11/2021