


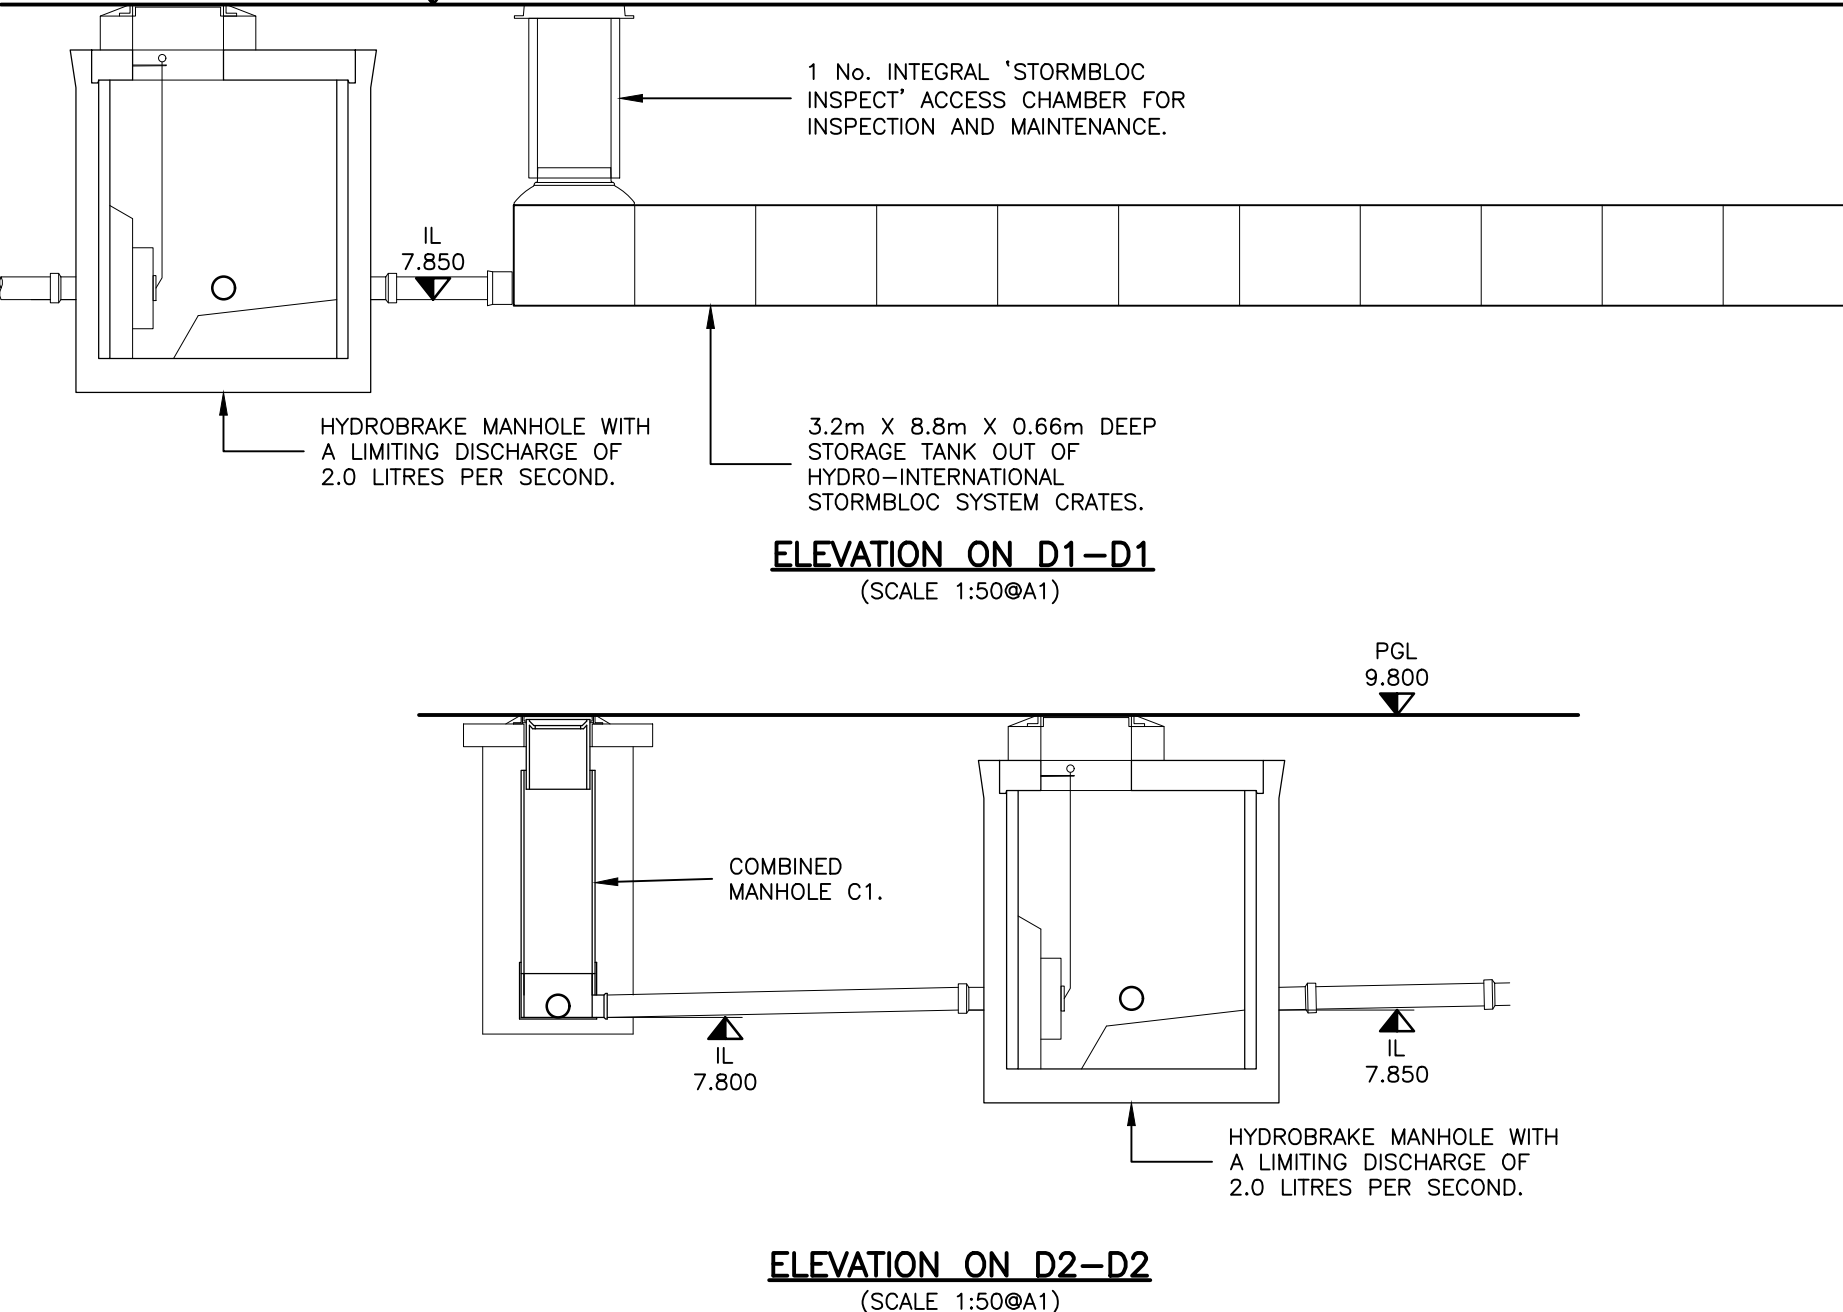

COMBINED MANHOLE SCHEDULE							
REF	COVER LEVEL	INVERT LEVEL	DEPTH TO INVERT	SIZE	TYPE	COVER	COMMENTS
C1	AS EXISTING	AS EXISTING		1200 DIA.	TYPE 2	675x675 D400	
C2	9.800	7.800	2.000	450#	TYPE 3	450x450 B125	

THIS DRAWING IS TO BE
READ IN CONJUNCTION WITH
DRAWING No.RRL012-551

DRAINAGE LAYOUT				
Scale 1:125	Paper Size A1	Date JUNE 2017	Drawn By JH	Checked By CH
Project No. RRL012		Drawing No. 505		Revision P3