


B

SITE / AUX TRANSFORMER


FLOOR PLAN

B

Technical drawing of a rectangular panel. The drawing shows a rectangle with a double-line border. The width is labeled as 2500 and the height is labeled as 6100. The drawing is oriented vertically on the page.

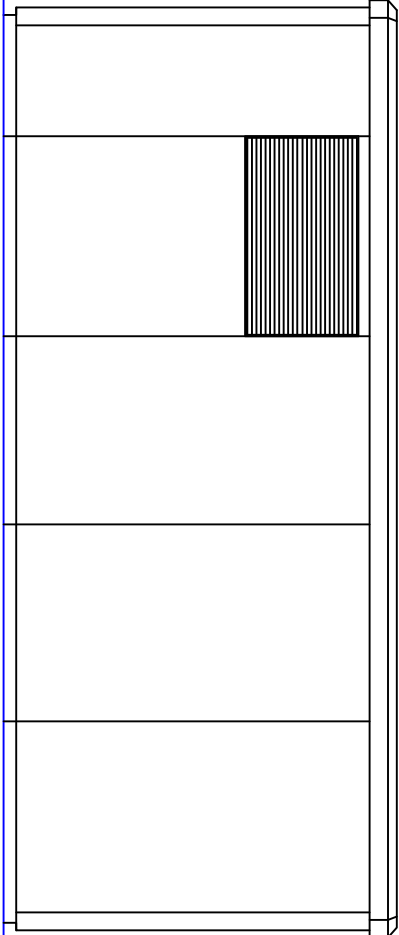

Technical drawing of a cabinet with a width dimension of 2600. The drawing shows a side view of the cabinet with a width of 2600. The cabinet has a top section, a middle section with a small horizontal handle, and a bottom section. The bottom section is divided into two parts: a left part with vertical hatching and a right part. The overall width is indicated by a dimension line at the bottom labeled 2600.

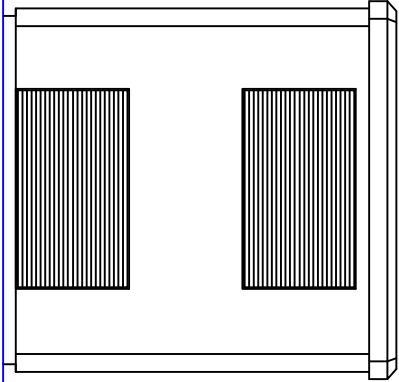

Revisions:					
A 15/05/13 Scale Rev Date Comments Dwn Cnkd					
AB DRAWN CHECKED APPROVED DATE 30.04.13					
PROJECT NAME:					
NOTES:					
Paper Size: A3	Scale: 1:50@A3	Sheet: SHEET#1			
DRAWING TITLE: SITE_AUX_TRANSFORMER_PLANS+ELEVATIONS					
DRAWING NUMBER: SITE_AUX_TRANSFORMER_01		STATUS: PRELIMINARY			
Lightsource Renewable Energy Limited, Level 5, 20 Old Bailey, London, EC4M 7AN General: +44 (0) 333 200 0755 Web: www.lightsource-re.co.uk info@lightsource-re.co.uk					