



Symbol	Qty	Article number	Article name
■	79	Lantern 10W	10W Half Lantern
●	13	LBDL4D40	Carbon Downlight 11W Dimmable

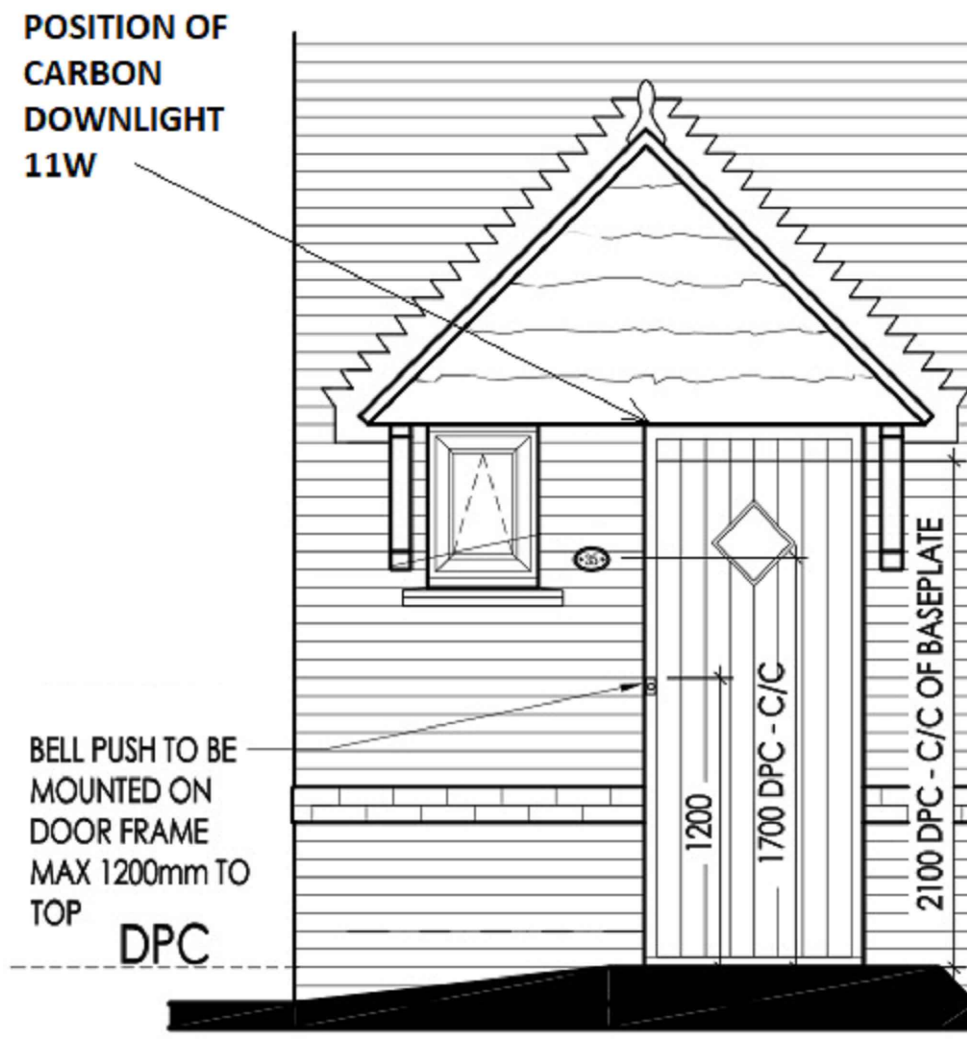

All downlights are @ 2.2m
All Wall Lights are @ 2.5m and are dimmable
Lamps are 3K or below, which has less effect on wildlife.
Calculation based on standard reflectance's.
Room/external area dimensions issued from customer.
PLEASE NOTE: All room/external area dimensions to be checked on-site prior to installation.
PLEASE NOTE: IT IS THE RESPONSIBILITY OF THE CONTRACTOR/INSTALLER TO CHECK ALL ROOM/EXTERNAL AREA DIMENSIONS ON-SITE PRIOR TO INSTALLATION.
Lighting designed to CIBSE guidelines where applicable and/or client requirements, all stated lux values are for overall averages across the room reference plane.
If dimmable luminaires have been specified, then it is the responsibility of the contractor to establish which dimming ballasts/system is required by the lighting control ethos/specification.
Lighting designed to issued lighting layout to establish projected light levels meet criteria.

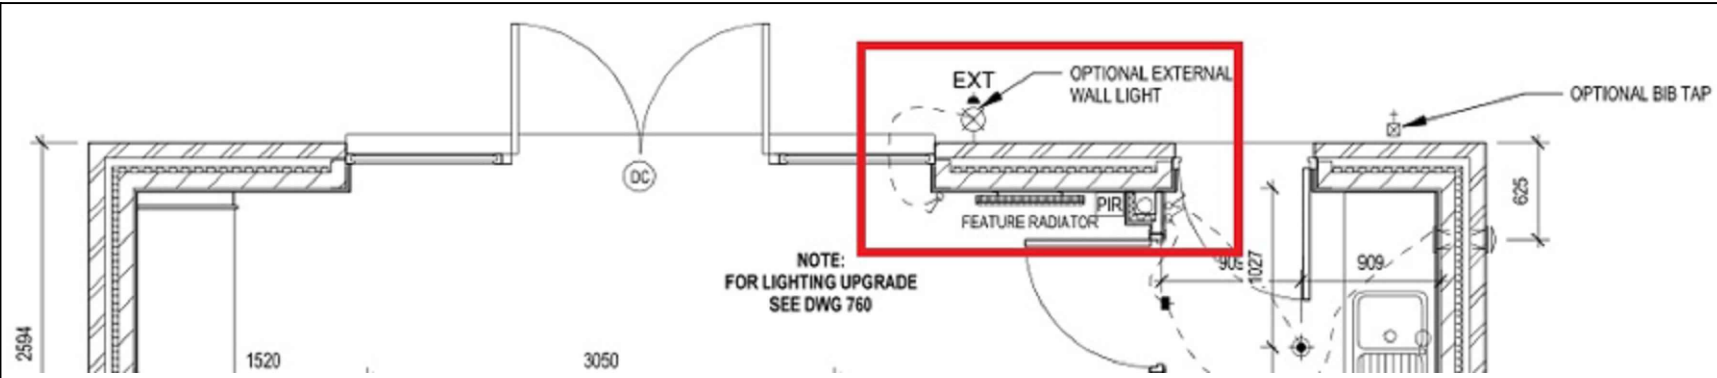

REV	AMENDMENT	DATE	INITIAL
R4	INITIAL DESIGN	09/08/2021	SW

MMA

LIGHTING CONSULTANCY

Exterior Lighting Design Specialists

99 Old Bath Road, Summer Field House, Reading, RG10 9QN
Phone: 0118 321 5636 Email: info@mma-consultancy.co.uk
www.mma-consultancy.co.uk

Project title	NORTH END ROAD, YAPTON		
Drawing title	HOUSE LIGHTING DESIGN SHEET 1 OF 1		
Prepared by	SW	Checked by	MD
Scale	NTS @ A1	Date	09/08/2021
Drawing Number	MMA15553/002		Revision Details R4