



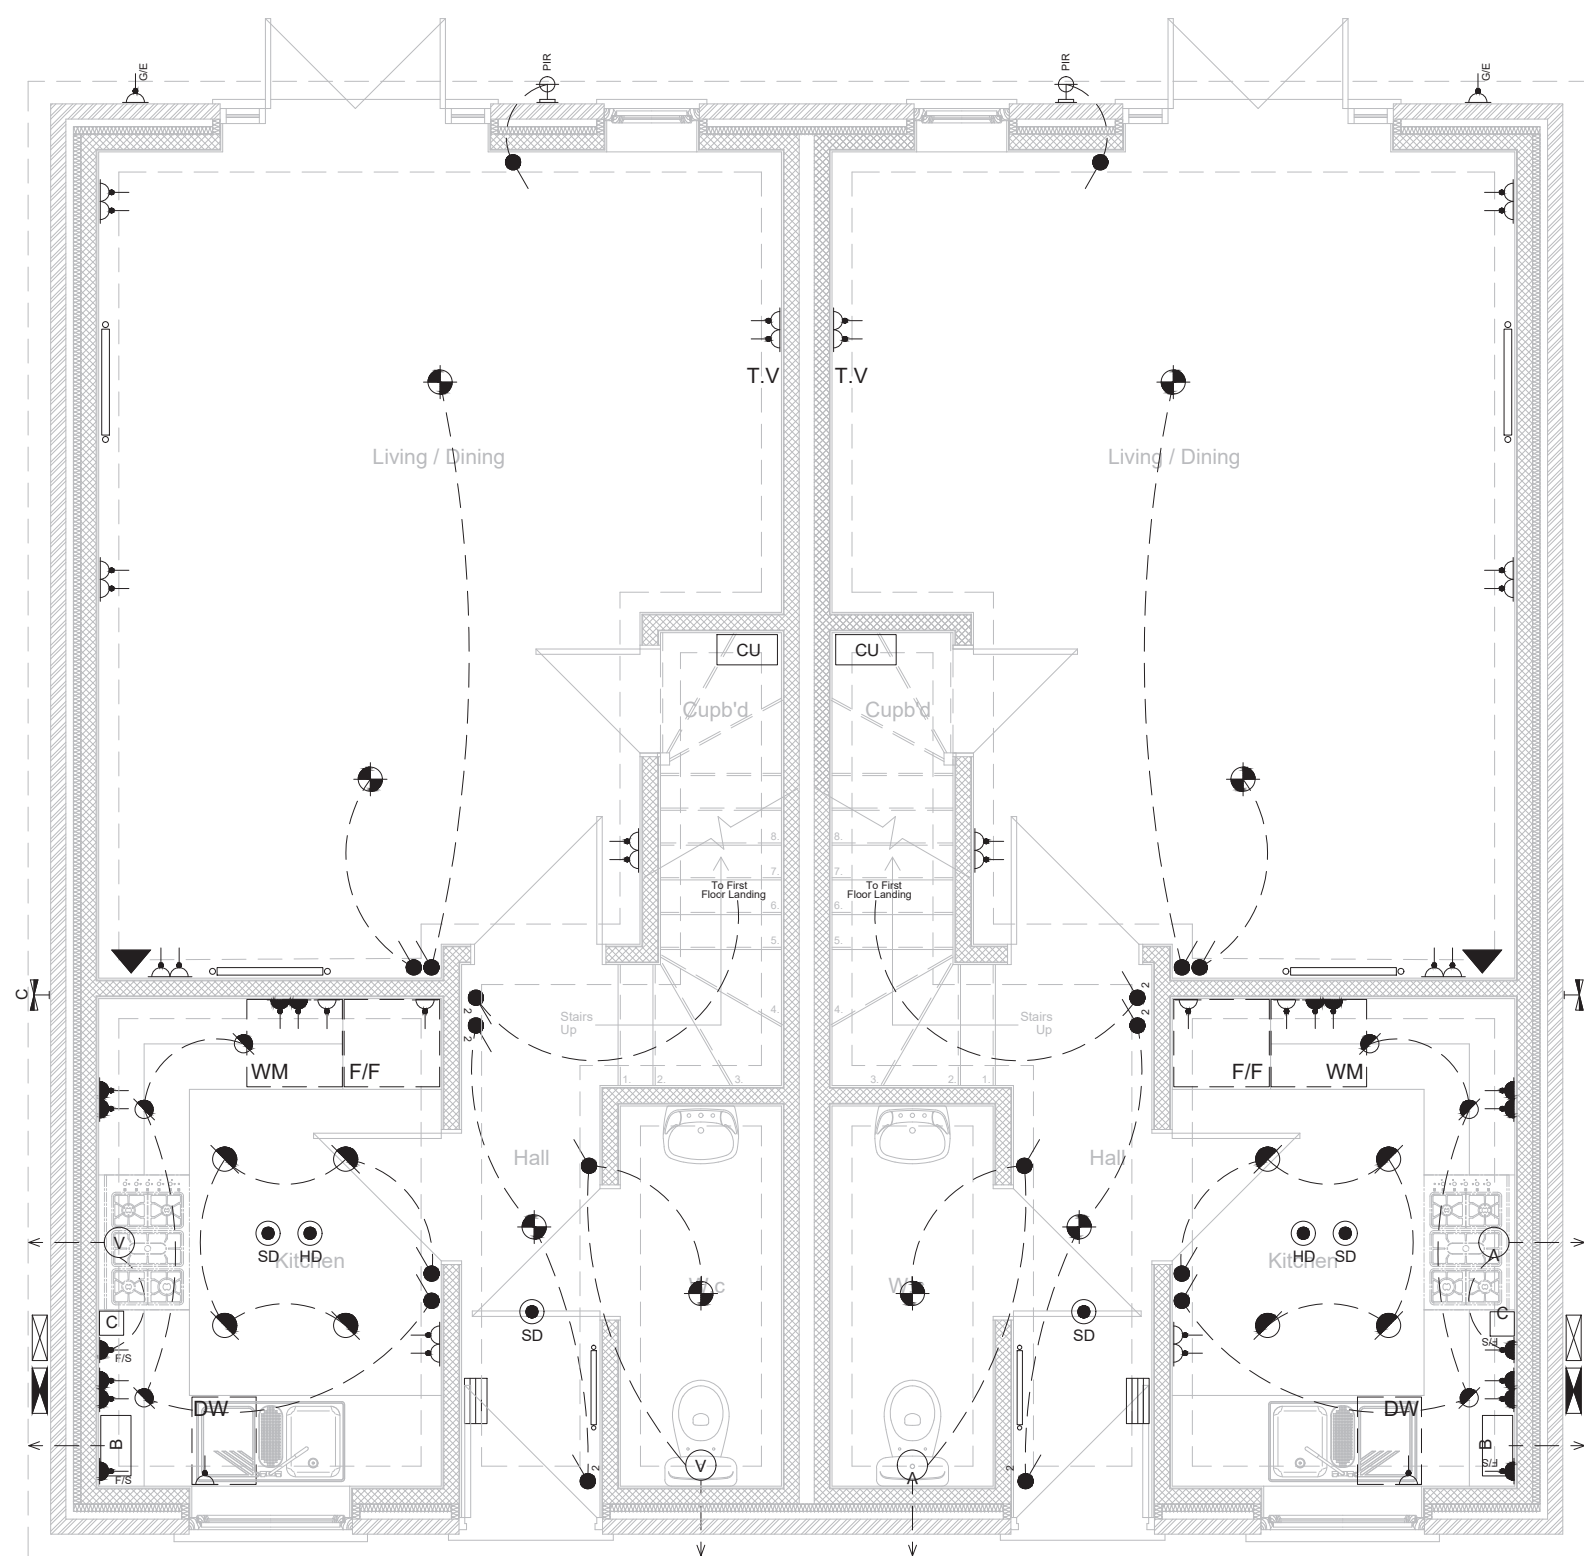


Proposed Ground Floor Electric Plan
Scale 1:50 @A1 / 1:100@A3


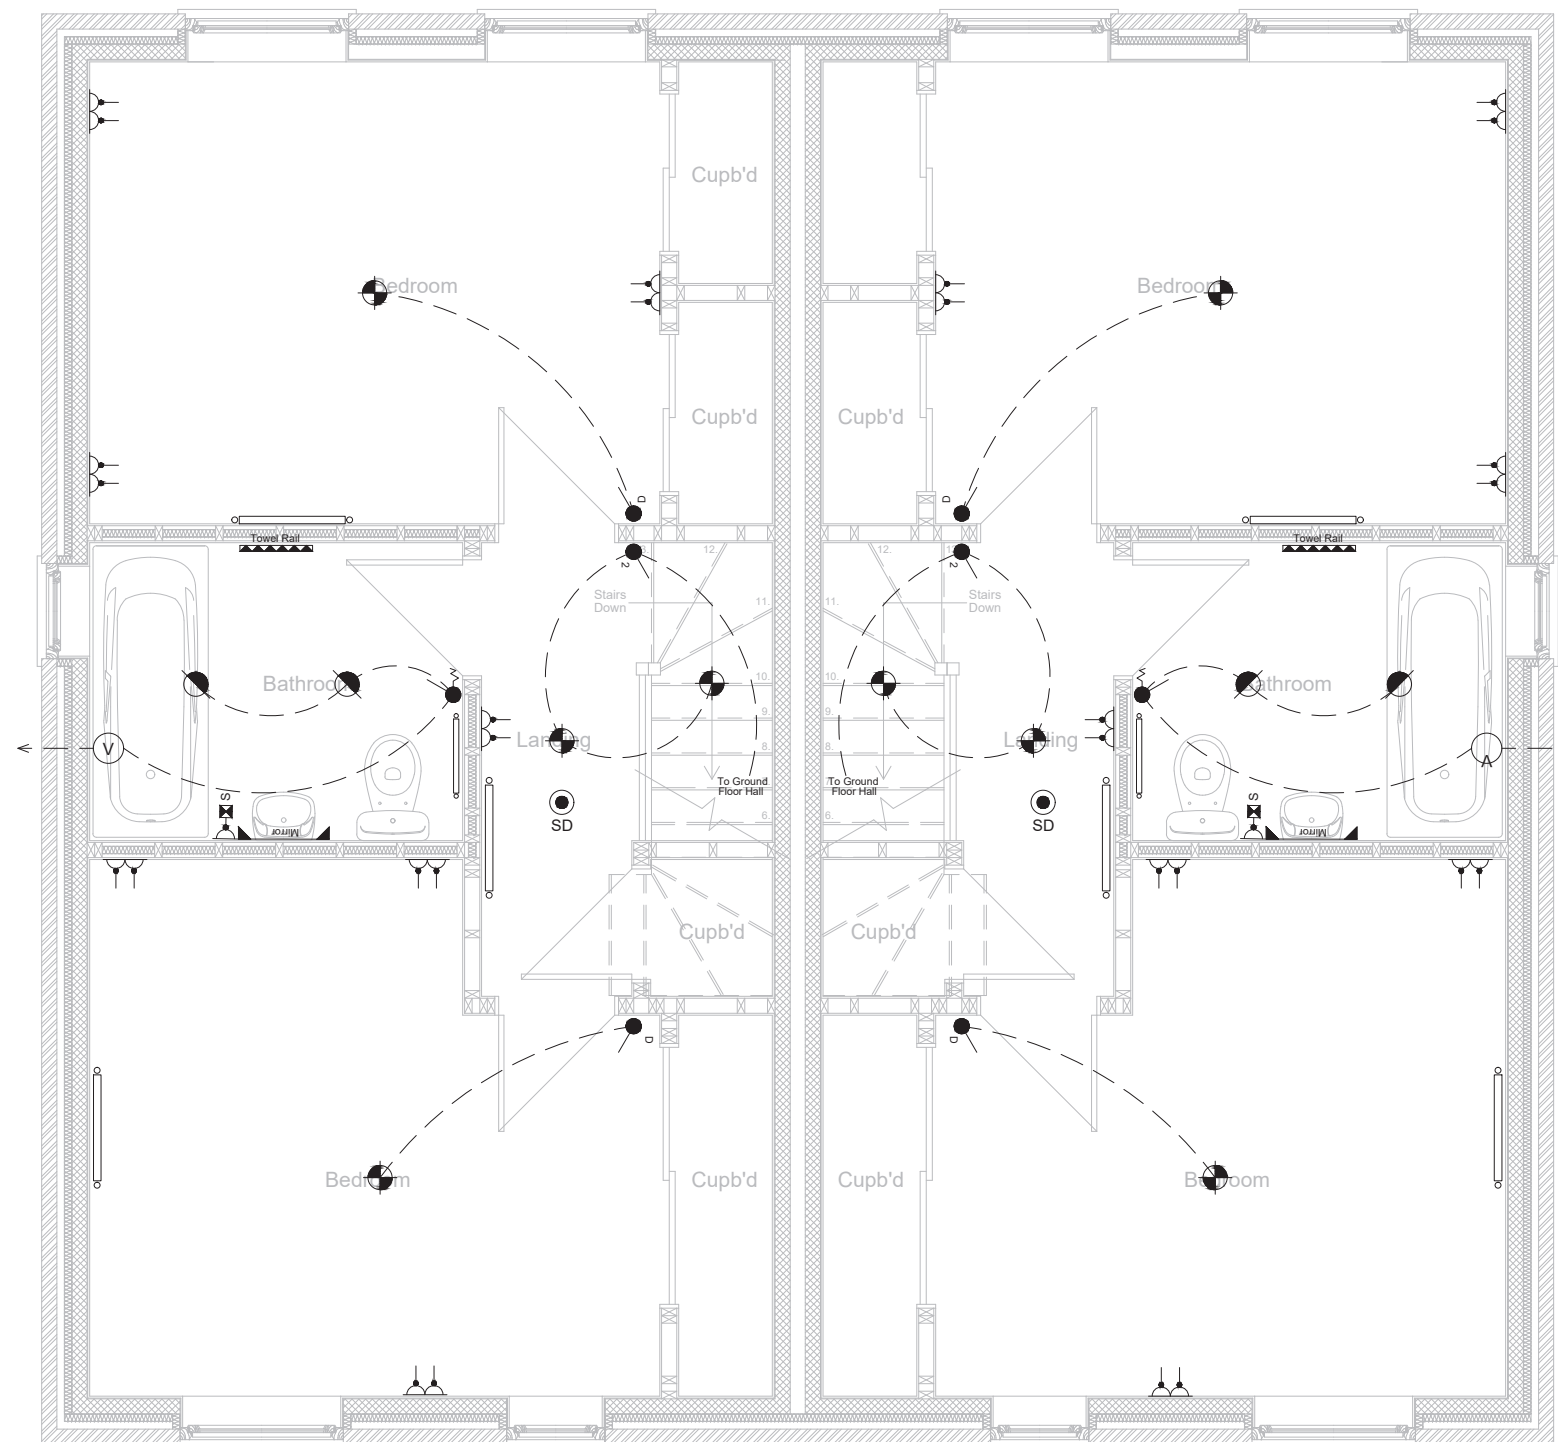


Proposed First Floor Electric Plan
Scale 1:50 @A1 / 1:100@A3


ELECTRICAL AND HEATING SPECIFICATION		
	13amp double power switch socket @ 450mm - 600mm High	 Copper Point
	13amp single power switch socket @ 450mm - 600mm High	 Exterior Cold Water Supply
	13amp double power switch socket @ 1100mm High	 Electric Shaver Socket
	13amp single power switch socket @ 1100mm High	 Bathroom Mirror Light/shaver (combo)
	Fused Spur Power Point @ 450mm - 600mm High	 Telephone point
	Fused Spur Power Point @ 1100mm High	 T.V Aerial Output Socket
	Wall mounted light switch	 Mains feed Smoke / Heat Detector
	Wall mounted Dimmer light switch	 Mechanical Ventilation Extrator
	Wall mounted 2-way light switch	 Electric Towel Rail
	Wall mounted 2-way light dimmer switch	 Radiator with Thermostatic Radiator Valves (TRV's)
	Pull cord Light/Extractor Fan Switch	 Electricity Meter
	Low voltage recess mounted downlight (with transformer)	 Gas Meter
	Ceiling Mounted Pendant Light Fitting	 Wall Hung Boiler
	Garden/Exterior Light with PIR Sensor	 Consumer Unit (fuse board) with RCD Protection and Breakers
	Garden/Exterior Power Point	 Fire Alarm Panel

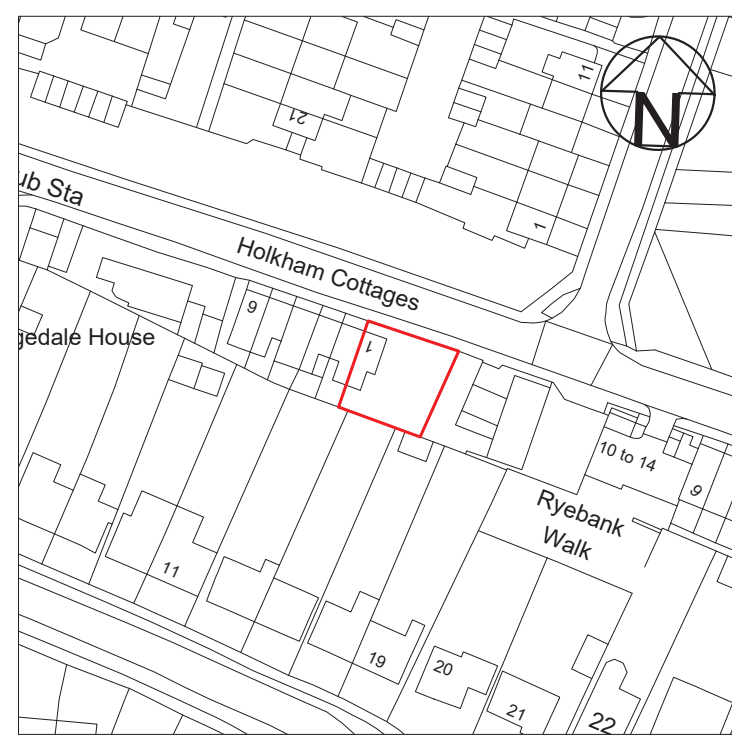

Location Plan (Existing)
Scale 1:1250 @A1 / 1:2500@A3

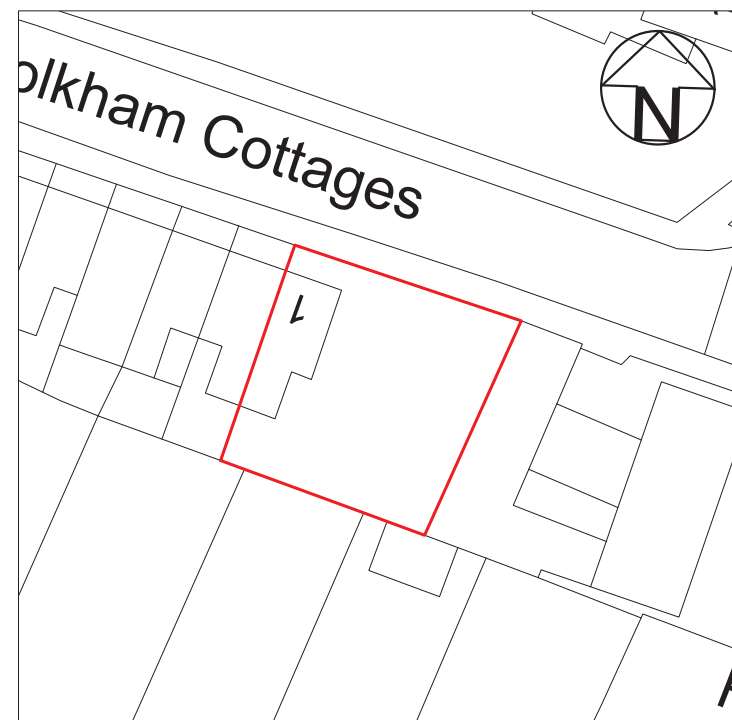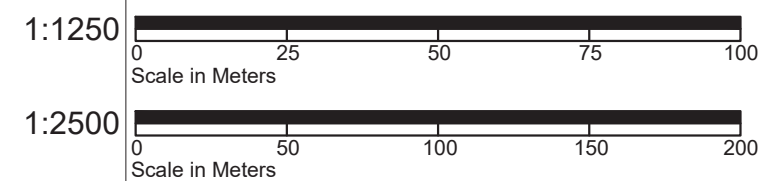

Site Plan (Existing)
Scale 1:500 @A1 / 1:1000@A3

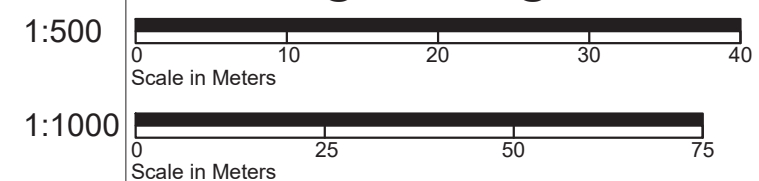

B	23.08.2018	Amendments to proposed lighting
Rev.	Date	Revision Detail / Comments



Client....

Machin Contractors

Project....

Burndell Road, Yapton

Drawing Title.....

Proposed Electric Plan

DWG No.....
2018/0044-06

Rev.....
B

Drawn By.....
RDS

Date.....	23.08.2018
-----------	------------

Drawing Scale....	Varies
-------------------	--------

Do Not Scale off Drawings
Check all Dimensions on site before all works are commenced
All Goods, Materials & Workmanship to conform with current Building Regs
© Copyright of Rob Shepherd Designs

Rob Shepherd Designs
Email: rob.brightonbuildingplans@gmail.com Tel: 07917 331264
87a Mile Oak Road, Portslade, Brighton, Sussex. BN41 2PJ