


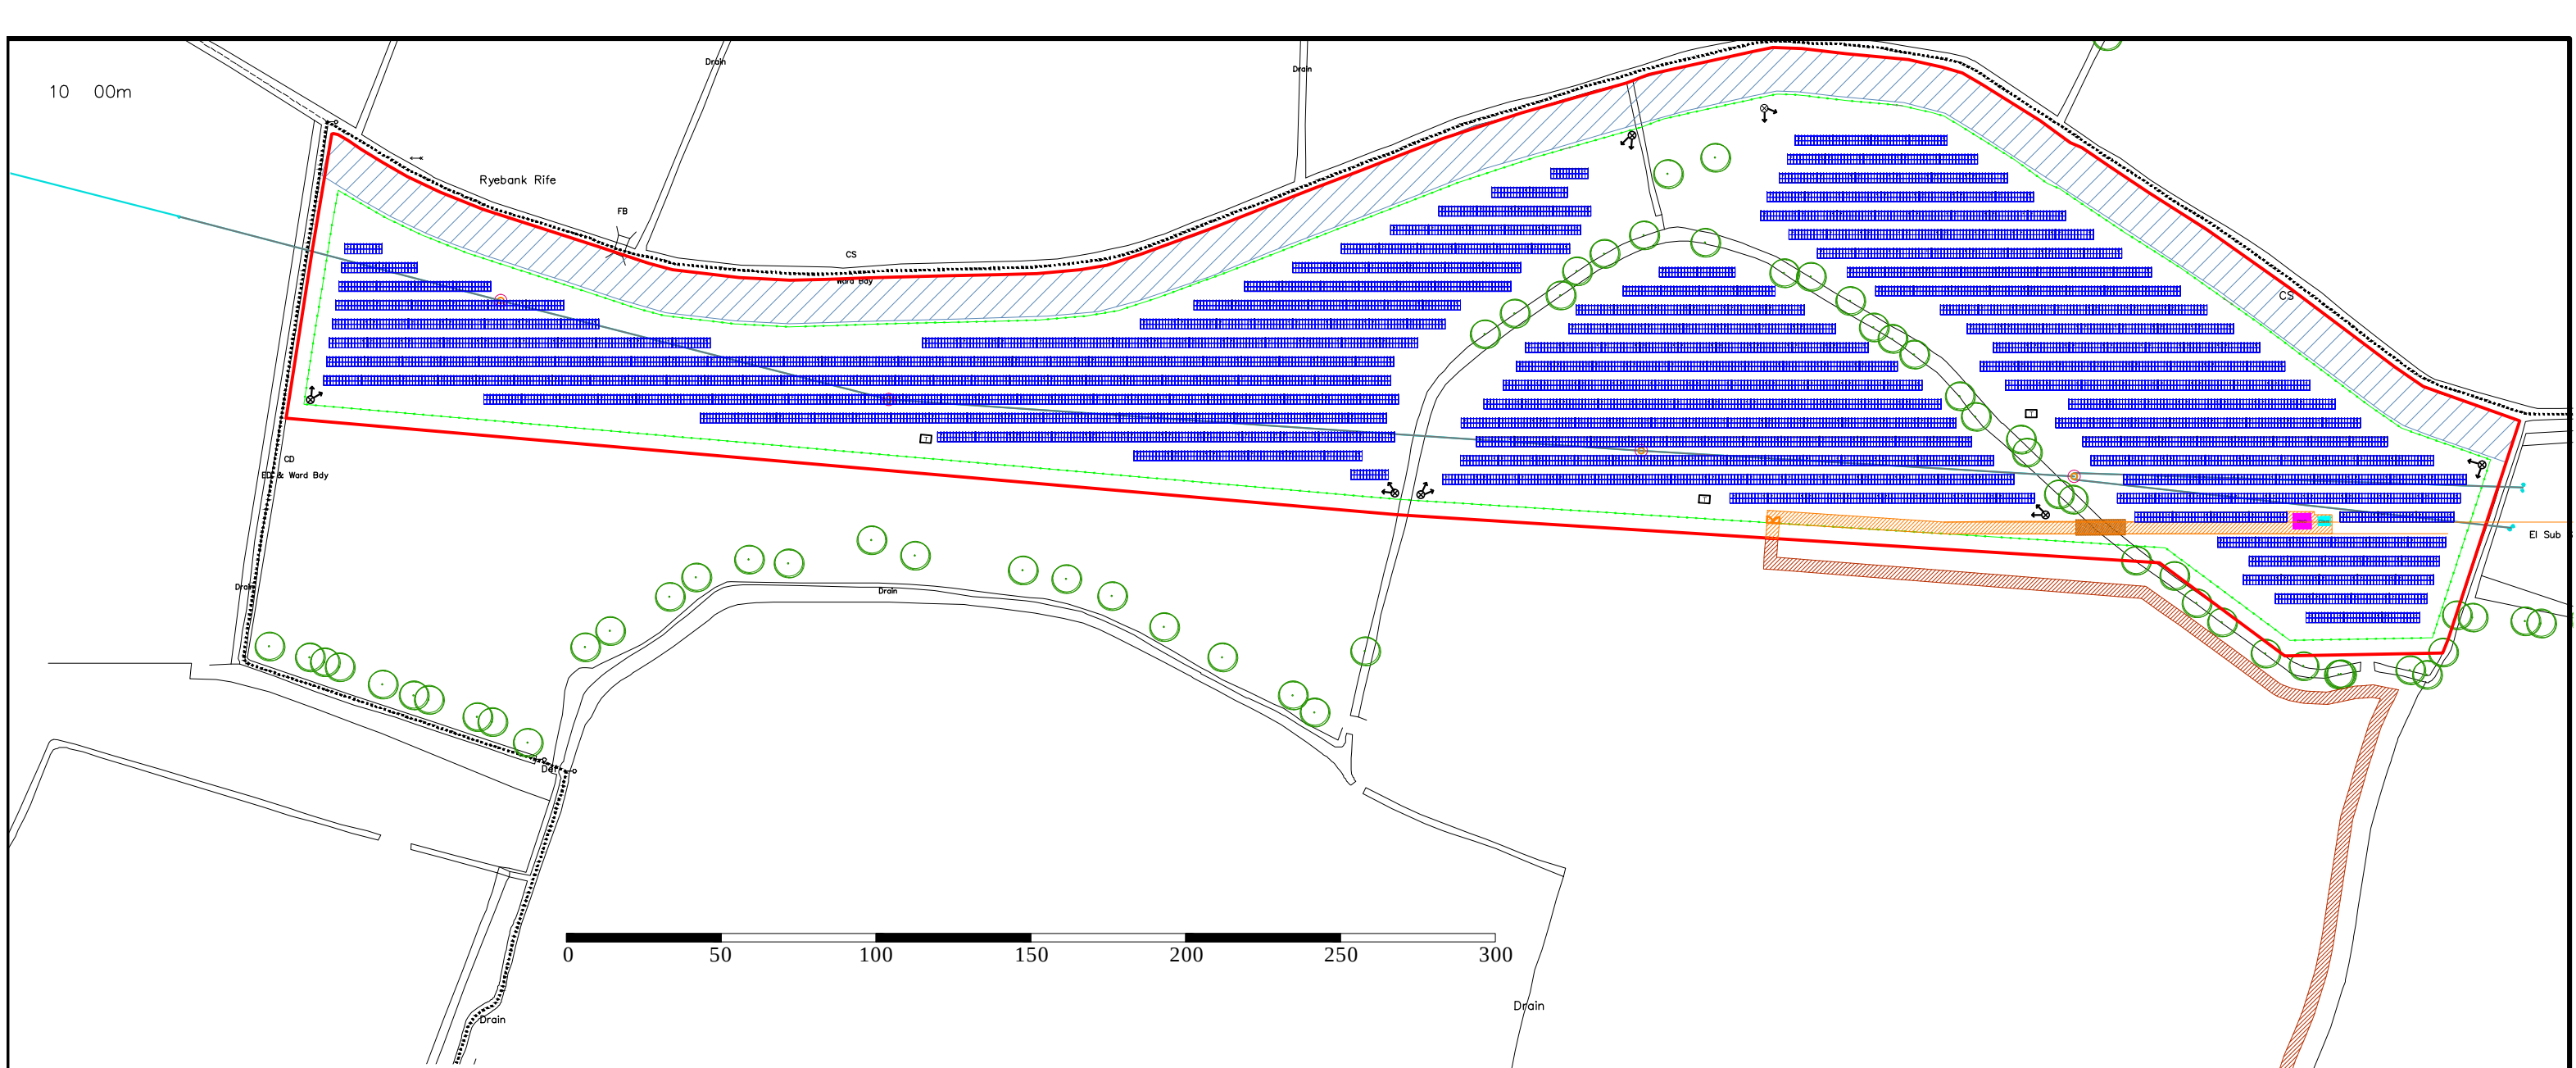

Technical information:


Total power: 3.833kWp

Modules: polychrystalline  
Modules dimension: 1650 x 992 x 50  
Assembly format: Portrait  
Modules capacity: 250 W  
Number of modules: 12216  
Total number Strings: 509  
Modules per String: 24  
Inverter: Huawei  
Table angle: 25°  
Modules per Table: 2 x 12 = 12 total  
Number of Tables: 509

Parcel data

Size of: ca. 17,91 acres  
Shading angle: 15,7°  
Coordinates: 50°48'22"N, 0°37'32"W  
Height above sea level: 0 - 1 m  
Wind load zone: ( II ) 21 - 23 m/s  
Snow load zone:  
Transfer station:  
Supply:  
Fence:  
Gate: 1

Example trenches

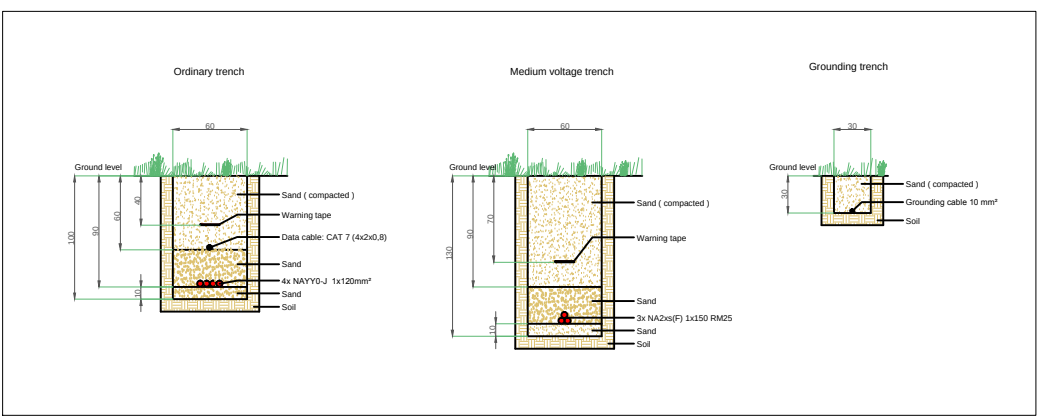

Key:



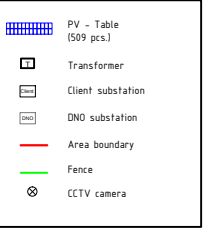


Table side view

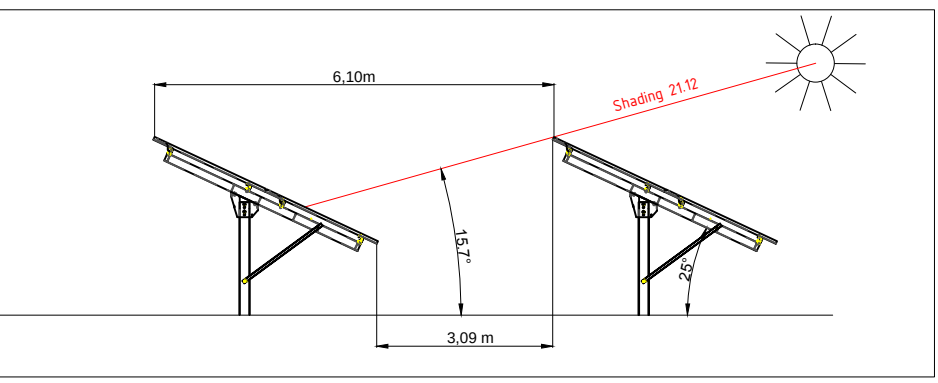

Example transformer side view

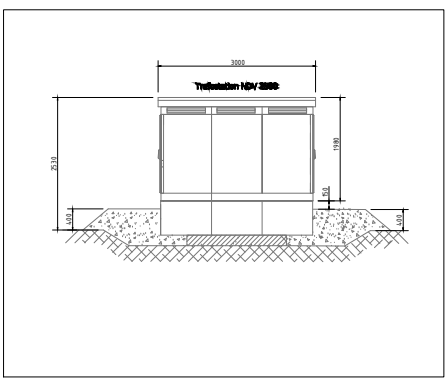

|                                                         |          |      |                                                  |                 |            |
|---------------------------------------------------------|----------|------|--------------------------------------------------|-----------------|------------|
| 2014                                                    | date     | name | Project: Rookery Farm<br>West Sussex, UK         |                 |            |
| changed:                                                |          |      |                                                  |                 |            |
| changed:                                                | 17.10.14 | E.K. |                                                  |                 |            |
| drawer:                                                 | 29.09.14 | R.P. |                                                  |                 |            |
| Scale: none                                             |          |      | Designation: PV Plant with CCTV system<br>Layout |                 |            |
| Total Power<br>3,054 MWp                                |          |      |                                                  |                 |            |
|                                                         |          |      | Status                                           | drawing number  | paper size |
| 2015-01-20 PV Rookery Farm_ CCTV plan.dwg<br>20/01/2015 |          |      | Entwurf                                          | 14-09-ROKUK-101 | A3         |

ARUN DISTRICT COUNCIL YB615DOC